



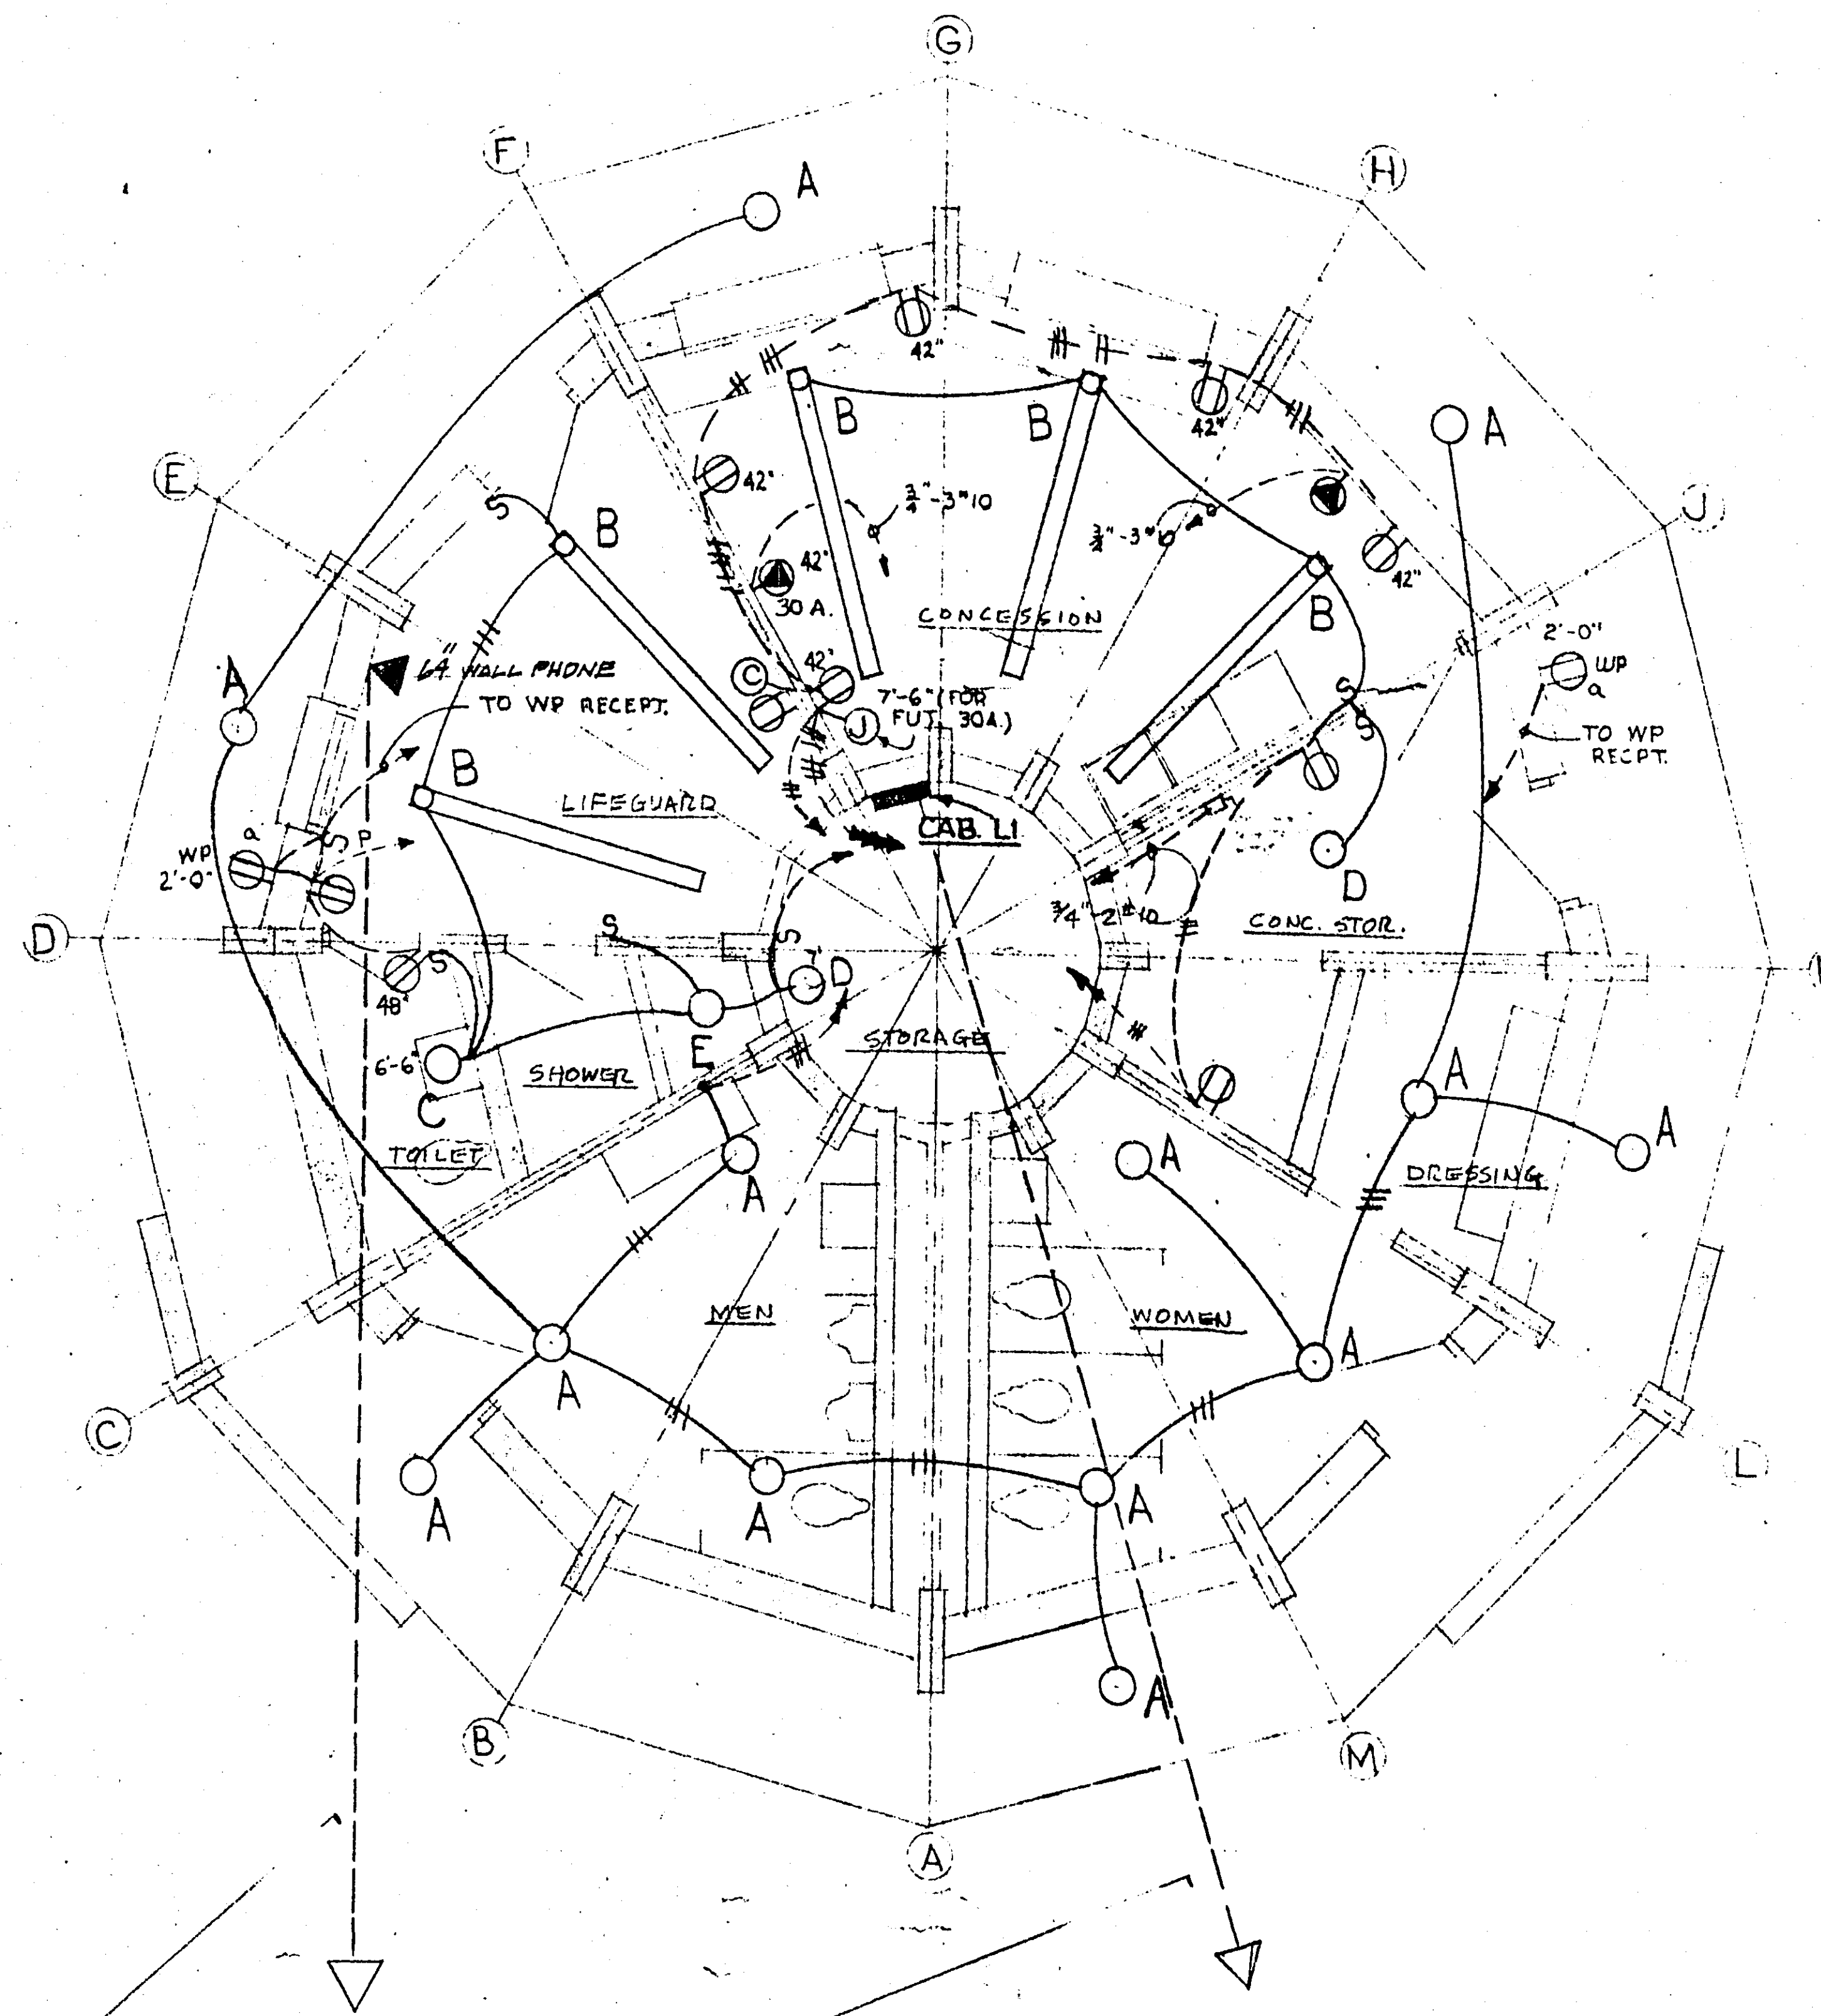

① MAKE UNDER GROUND SERVICE CONNECTIONS TO N&P AND NORTHWESTERN BELL UTILITY SERVICES AS REQUIRED AND AS SHOWN ON ATTACHED SITE PLAN. VERIFY DIRECTION OF SERVICE ENTRANCE AS THIS MAY VARY WITH PARTICULAR SITE AND BUILDING ORIENTATION.

FLOOR PLAN
SCALE 1/4"=1'-0"

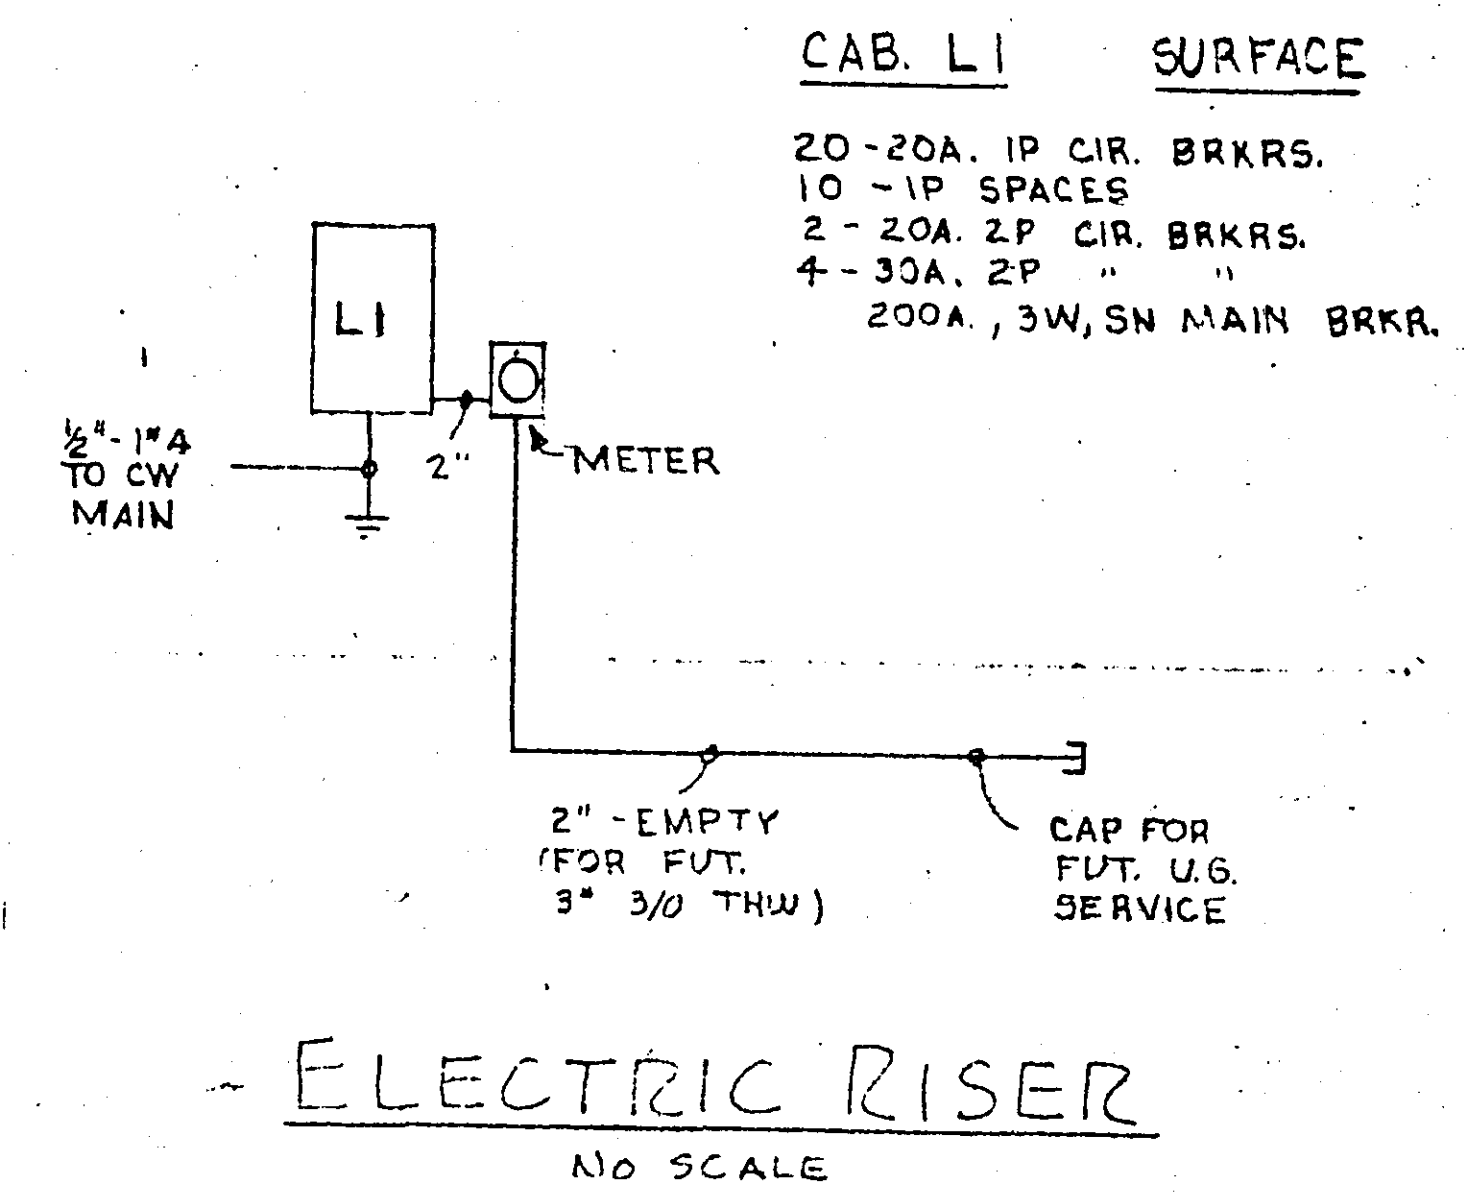

REFECTORY BUILDING FOR RAMSEY COUNTY
LAKE JOSEPHINE - RAMSEY COUNTY MINNESOTA
DESIGNED BY RAMSEY COUNTY ENGINEER


① GENERAL REVISION ONLY 6-12-68

DATE
3-21-67

PLAGENS MCGEE ANDERSON SJOVERTSEN INC.
ARCHITECTS AND ENGINEERS - 533 ST. CLAIR AVE. ST. PAUL, MINN. 55104

MICROFILMED
RAMSEY CO. ENGR.

E
16-121


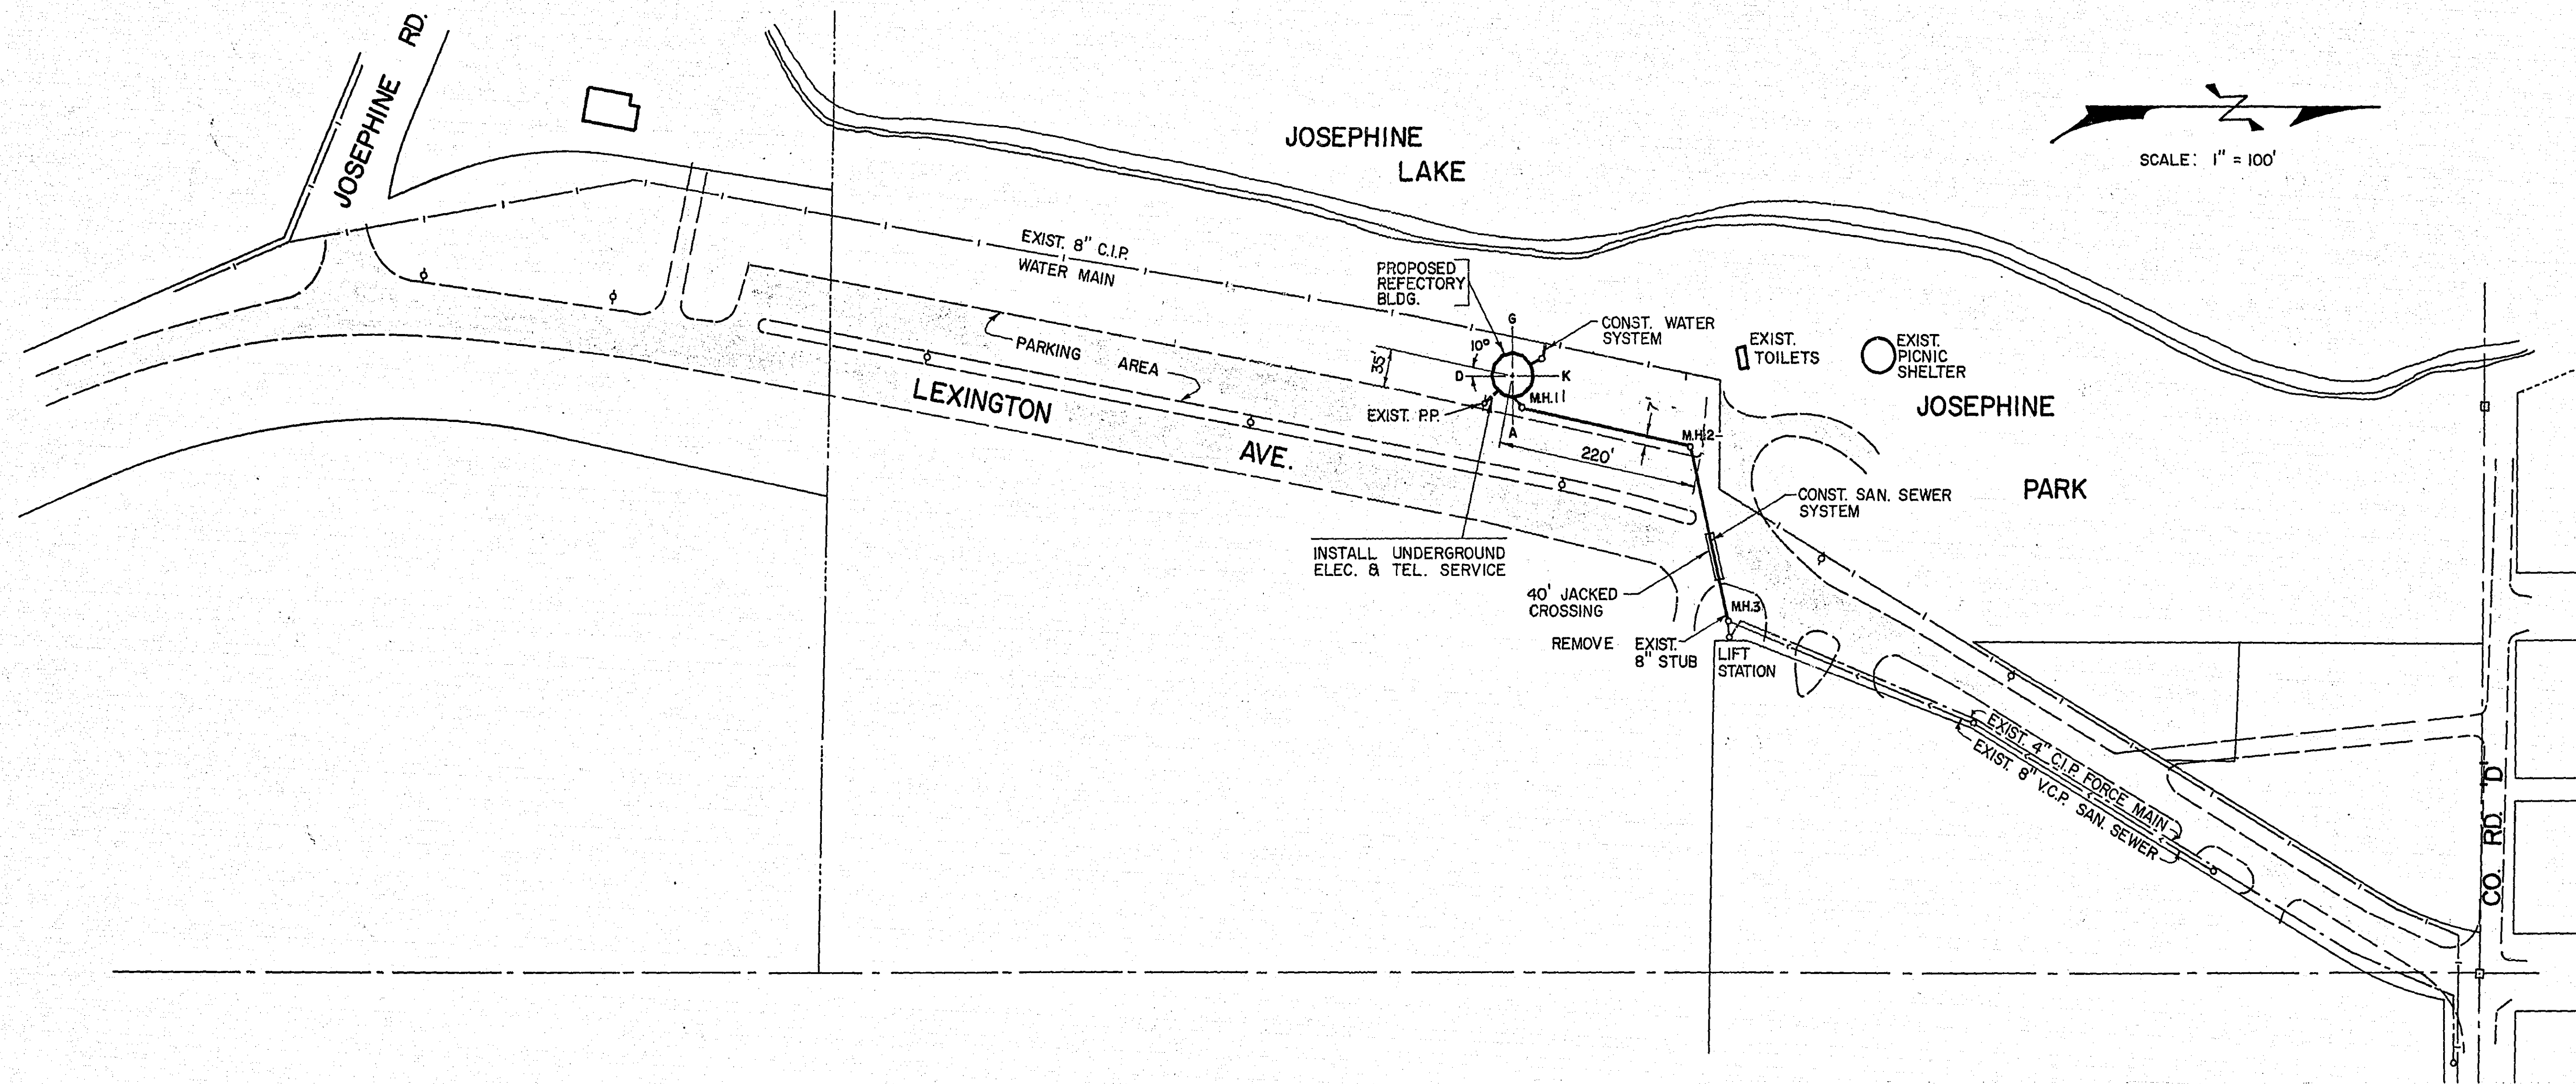


GENERAL NOTES

1. THE CONTRACTOR SHALL MAKE THE ARRANGEMENTS WITH THE VILLAGE OF ROSEVILLE FOR THE WATER AND SEWER CONNECTIONS AND SHALL ASSUME ANY COSTS INCURRED FOR THESE CONNECTIONS.
2. BACKFILLING. THE CONTRACTOR SHALL BACKFILL AND COMPACT THE TRENCHES, UNSUITABLE MATERIAL SHALL BE REMOVED AND REPLACED WITH PITRUN GRANULAR MATERIAL. IN THE GRASS AREA THE TOPSOIL SHALL BE REPLACED AND IN THE BITUMINOUS SURFACED AREA DISTURBED BY THIS CONSTRUCTION, THE CONTRACTOR SHALL REPLACE THE BITUMINOUS SURFACE AND CLASS 5 BASE AS REQUIRED BY THE PROVISIONS SET FORTH IN THE "CONDITIONS FOR THE INSTALLATION OF UTILITIES IN COUNTY ROAD RIGHTS-OF-WAY".
3. THE CONTRACTOR SHALL BID THE SEWER WORK WITH A JACKED CROSSING UNDER LEXINGTON AVENUE AS PART OF THE LUMP SUM BID. HE SHOULD ALSO STATE ON HIS PROPOSAL A DEDUCTION IF THIS JACKED HIGHWAY CROSSING IS ELIMINATED PRIOR TO CONSTRUCTION.
4. THE JACKED HIGHWAY CROSSING SHALL BE IN AN 8 INCH CAST IRON LOCK JOINT PLACED IN A MINIMUM 16 INCH LINER PIPE.
5. THE 8 INCH VITRIFIED CLAY PIPE FOR THE SEWER LINE SHALL BE EXTRA STRENGTH WITH PRE-MOLDED, FACTORY INSTALLED, TYPE 3 JOINTS, OR EQUAL.

B.M. 898.56
TOP HYD. N.W. COR.
PARKING AREA & LEXINGTON

SCALE: VERT. 1" = 5'
HORIZ. 1" = 50'

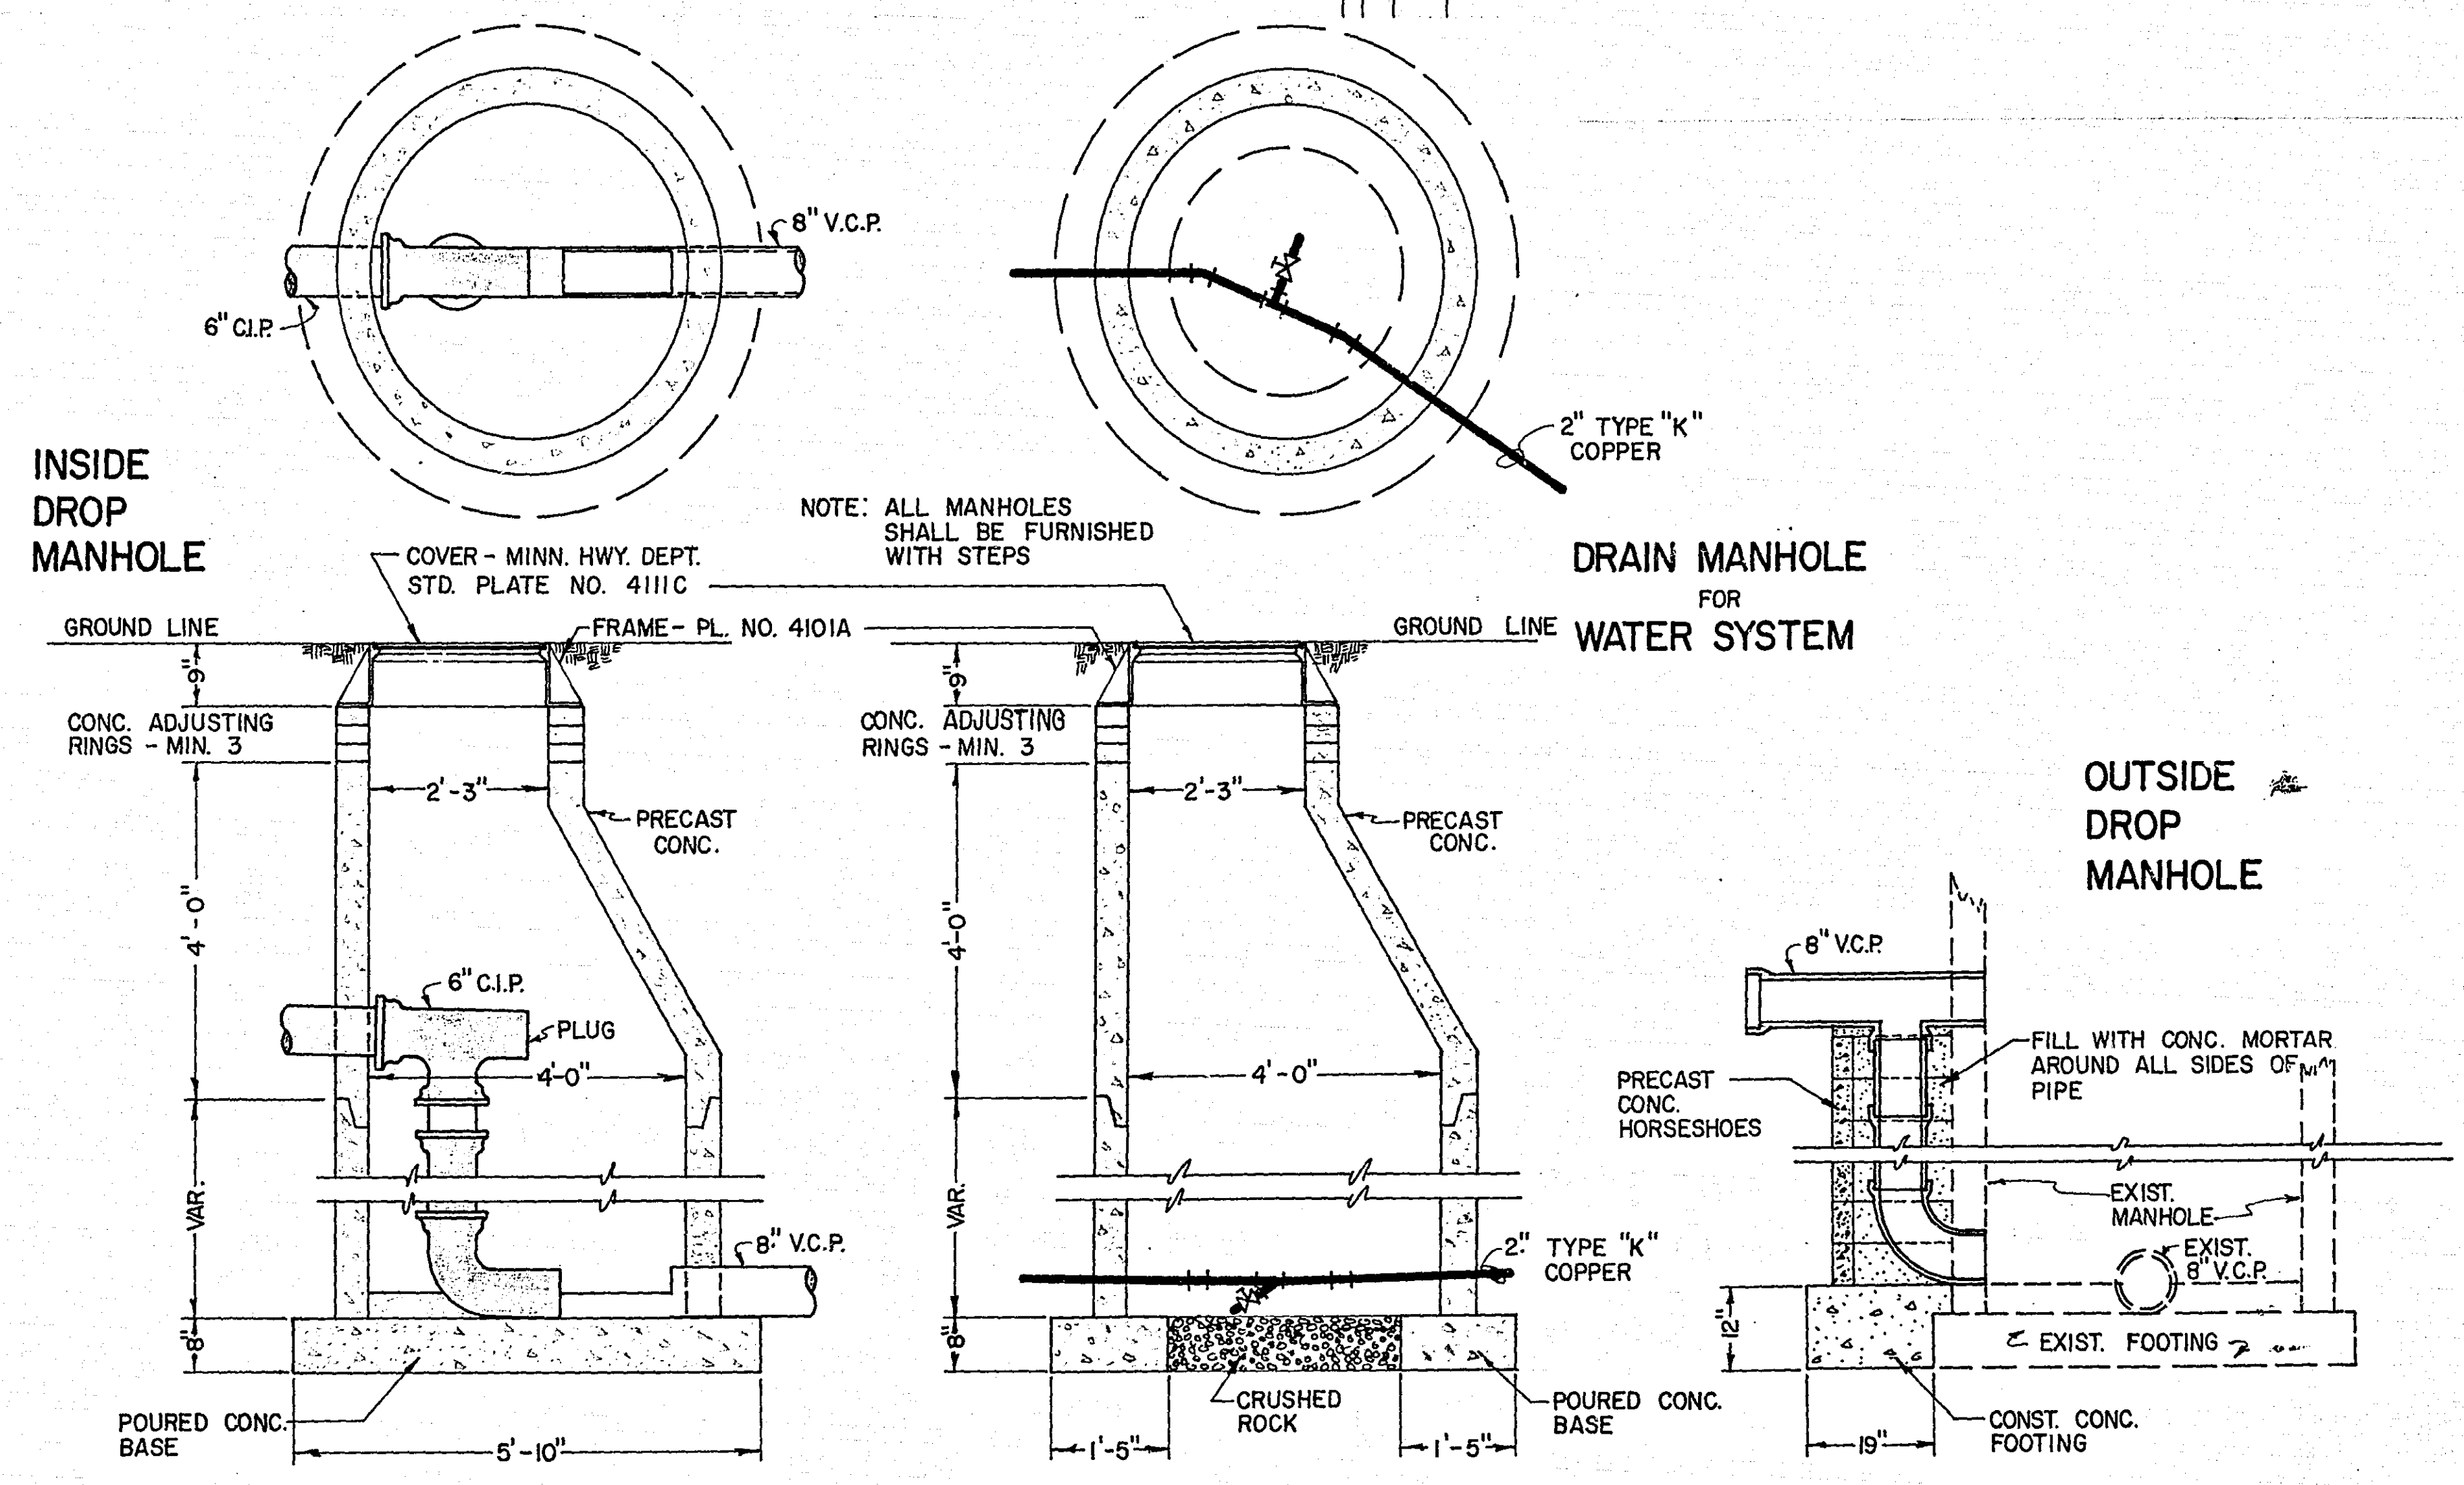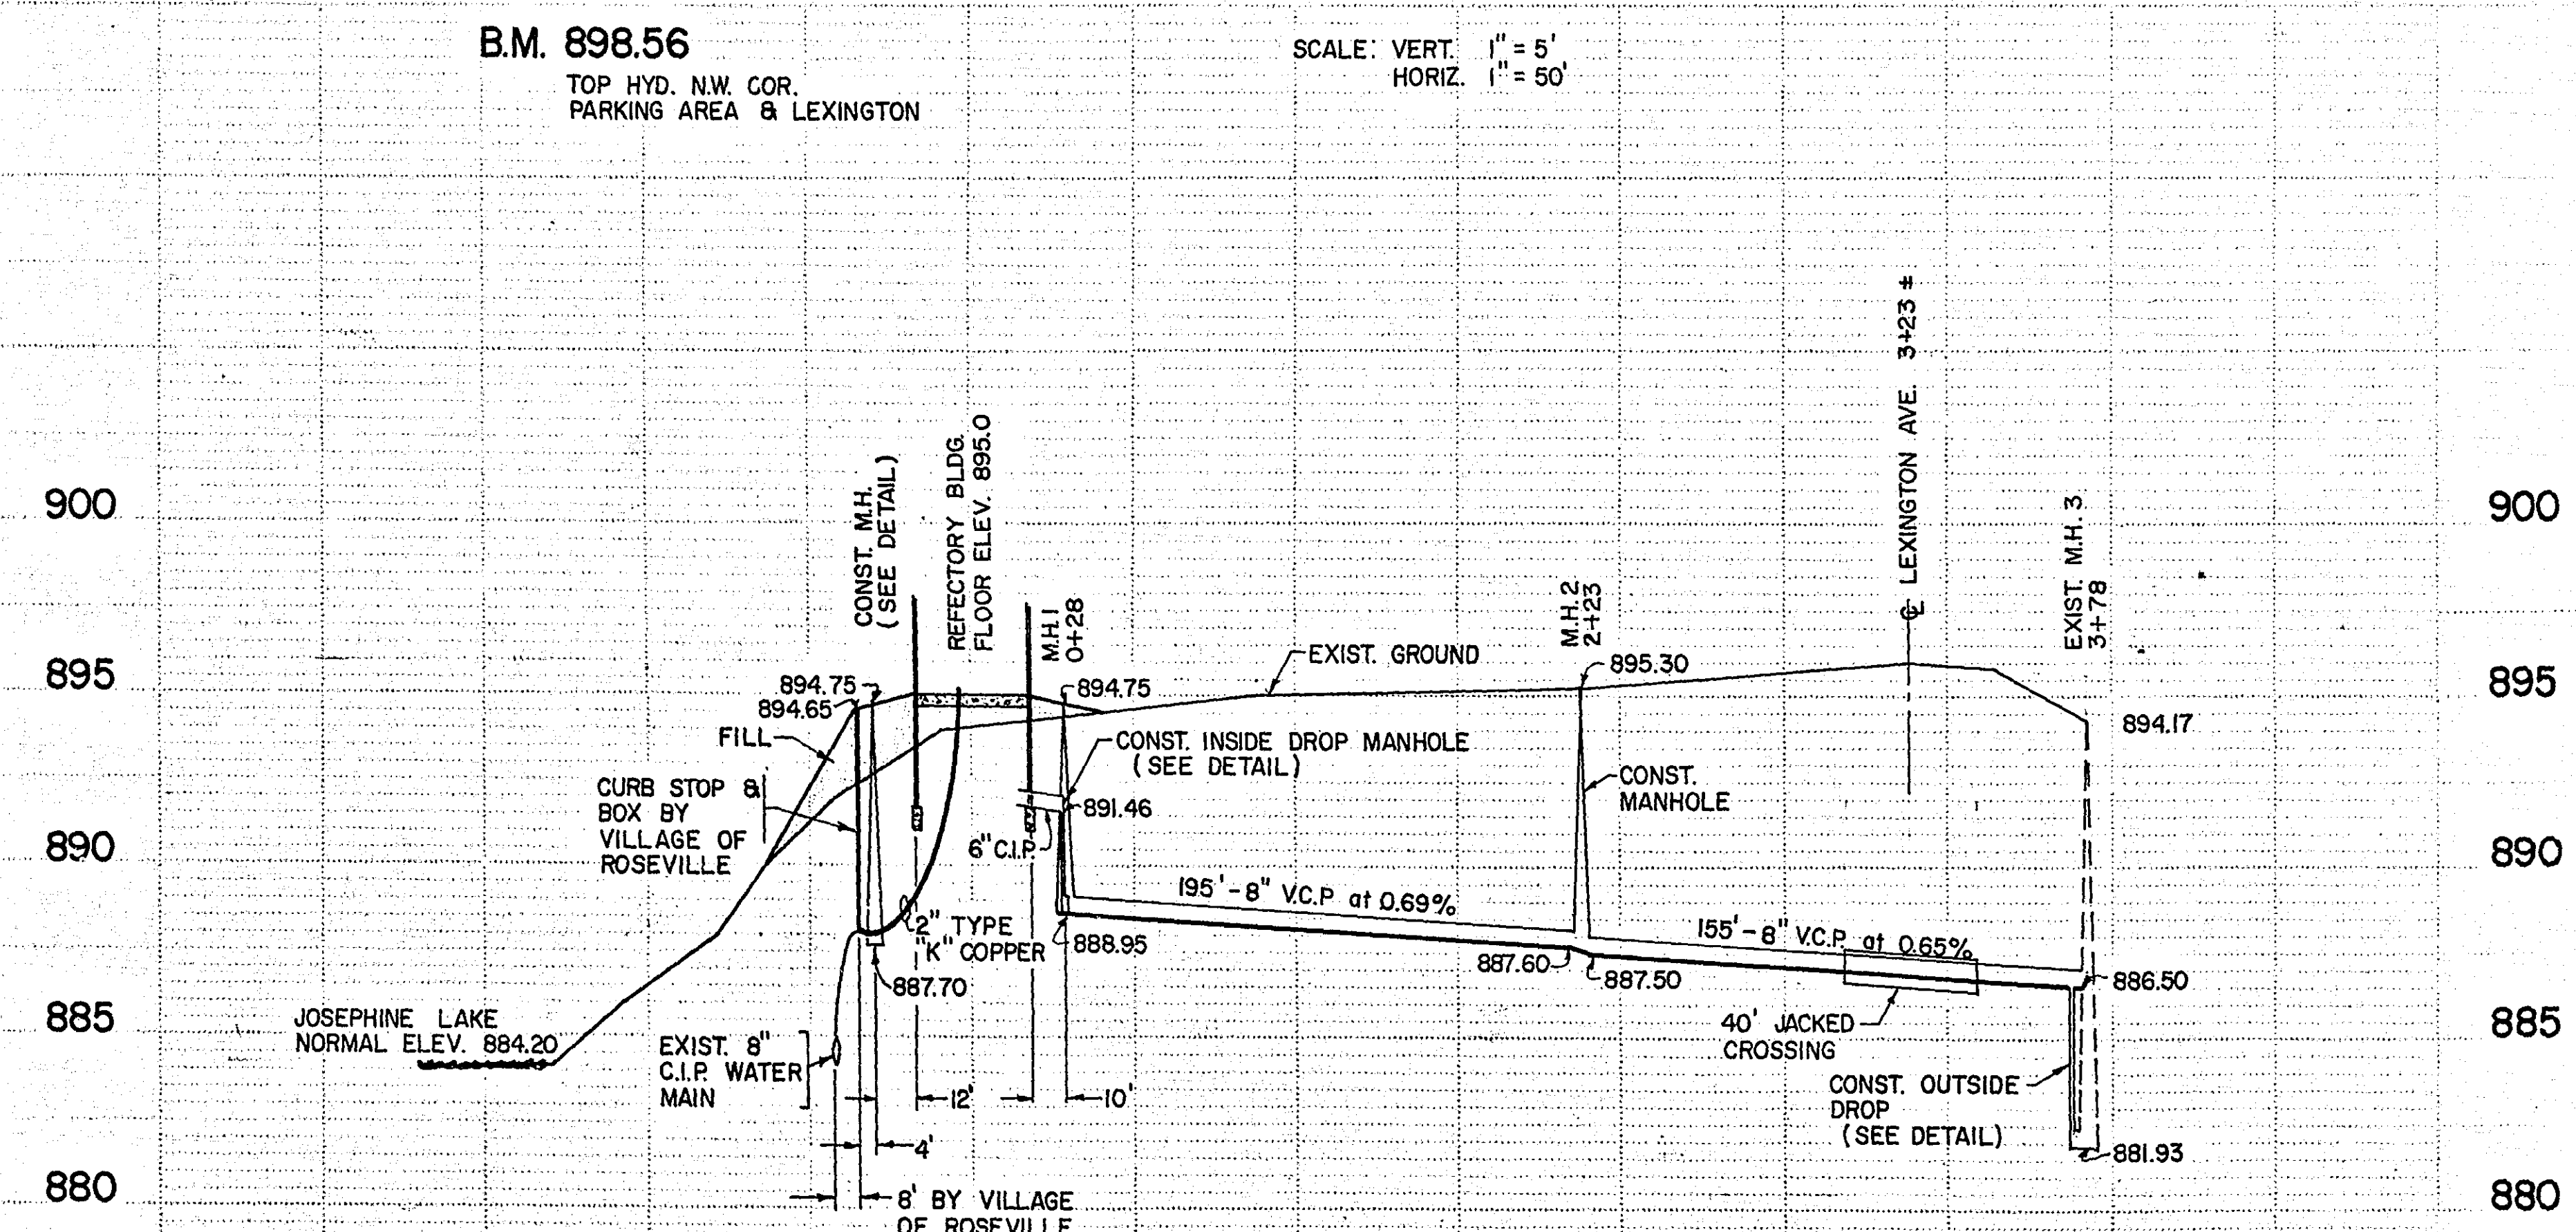

I hereby certify that this plan, specification, or report was prepared by me or under my direct supervision and that I am a duly Registered Professional Engineer under the laws of the State of Minnesota

Deane R. Anklan

Date 7-2-68 Reg. No. 7177






RAMSEY COUNTY ENGINEERS DEPT.

DEANE R. ANKLAN
COUNTY ENGINEER

SITE PLAN

DRAWN R.W.W.


MICROFILMED
RAMSEY CO. ENGR.

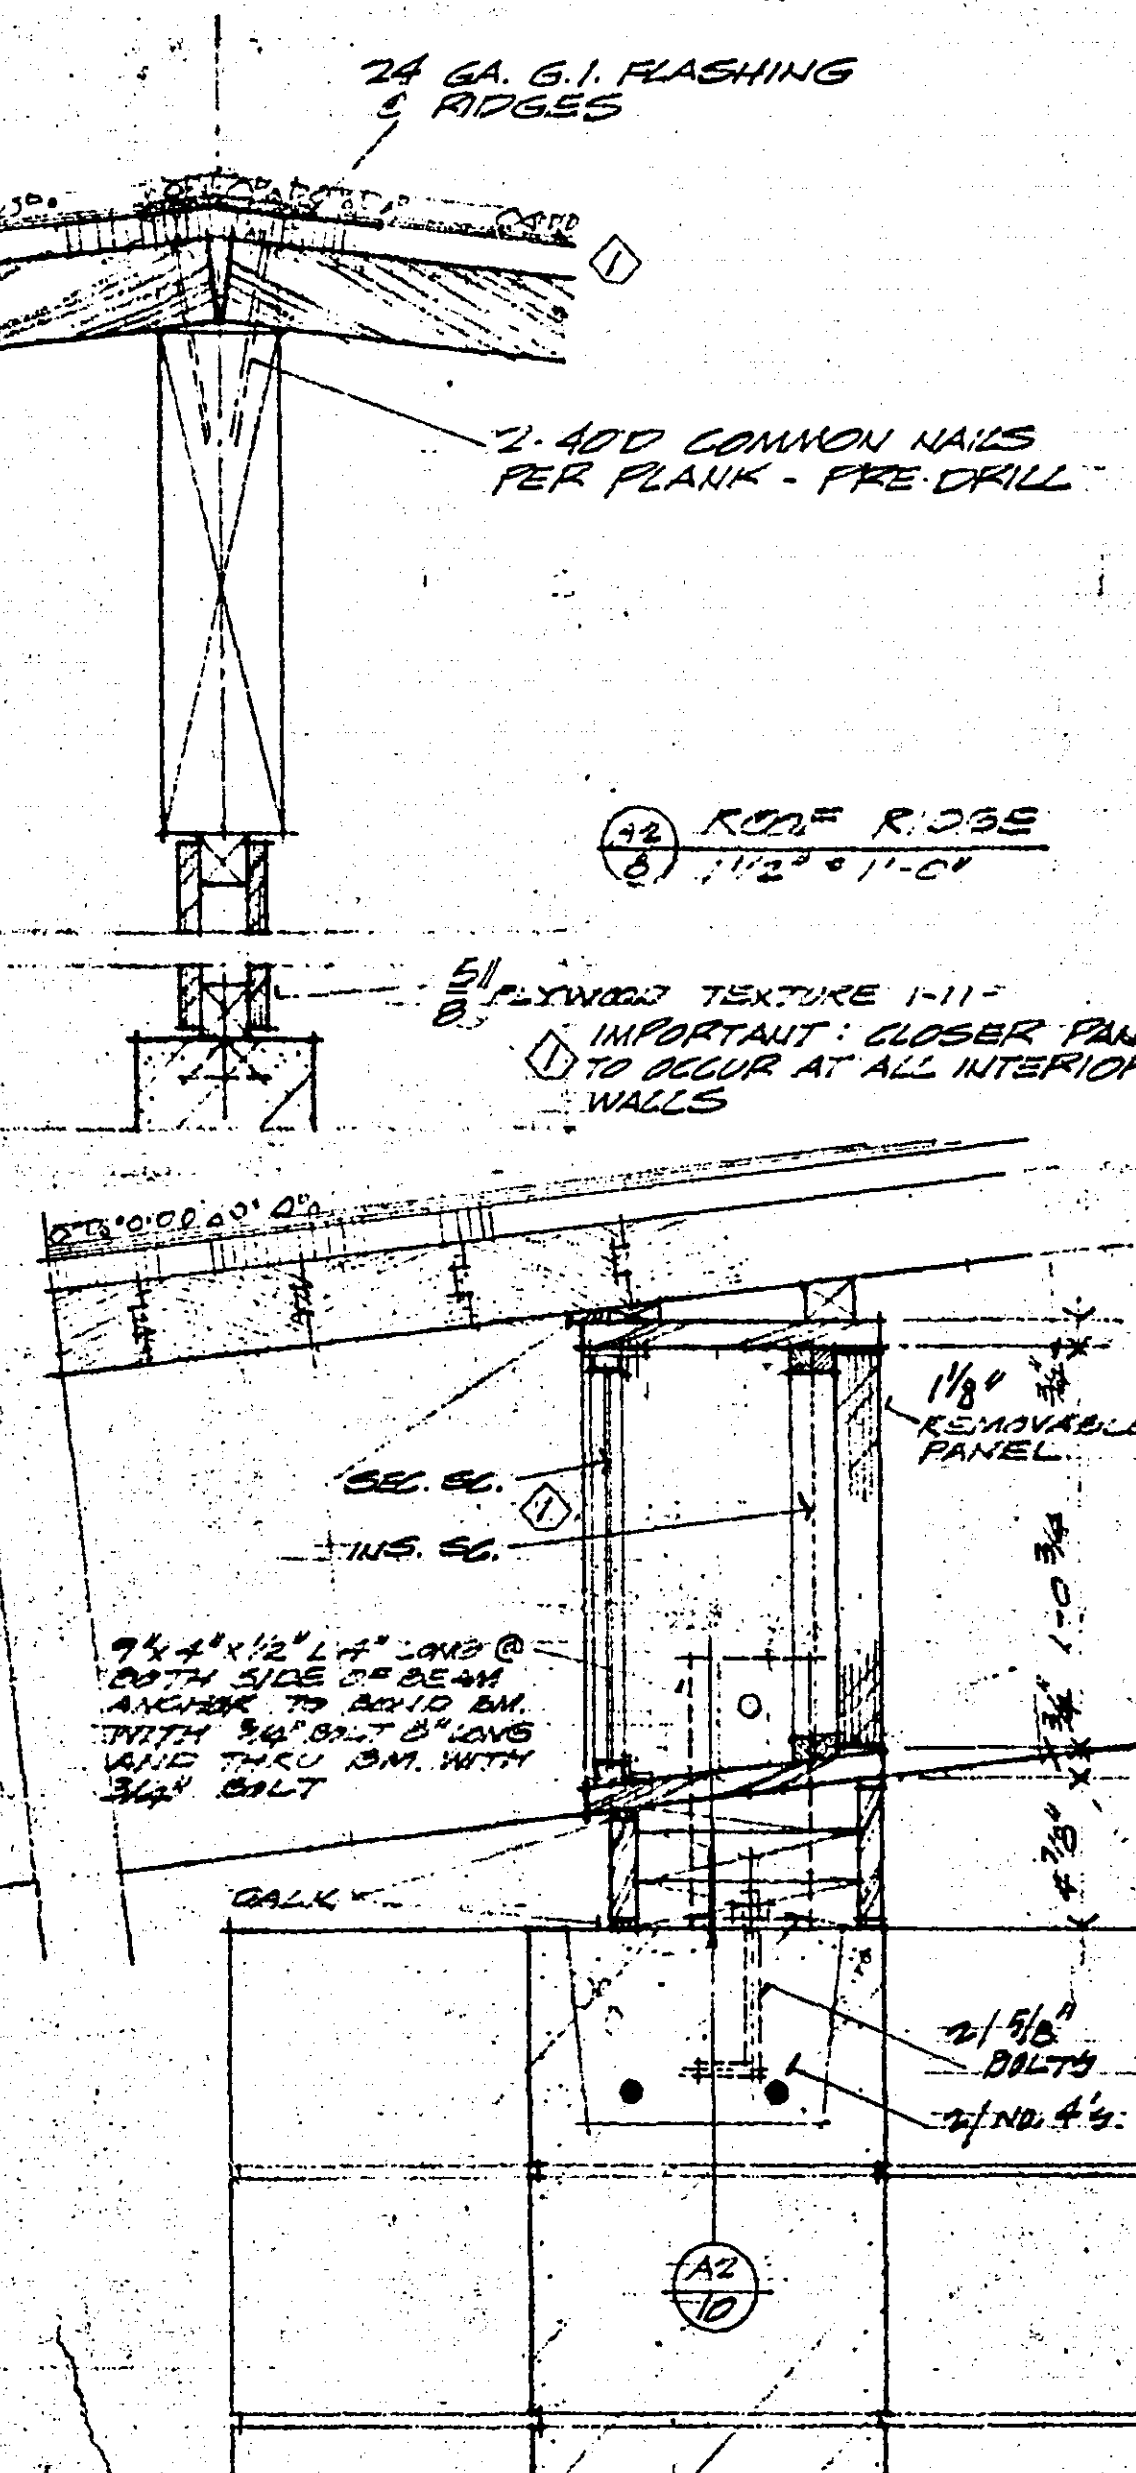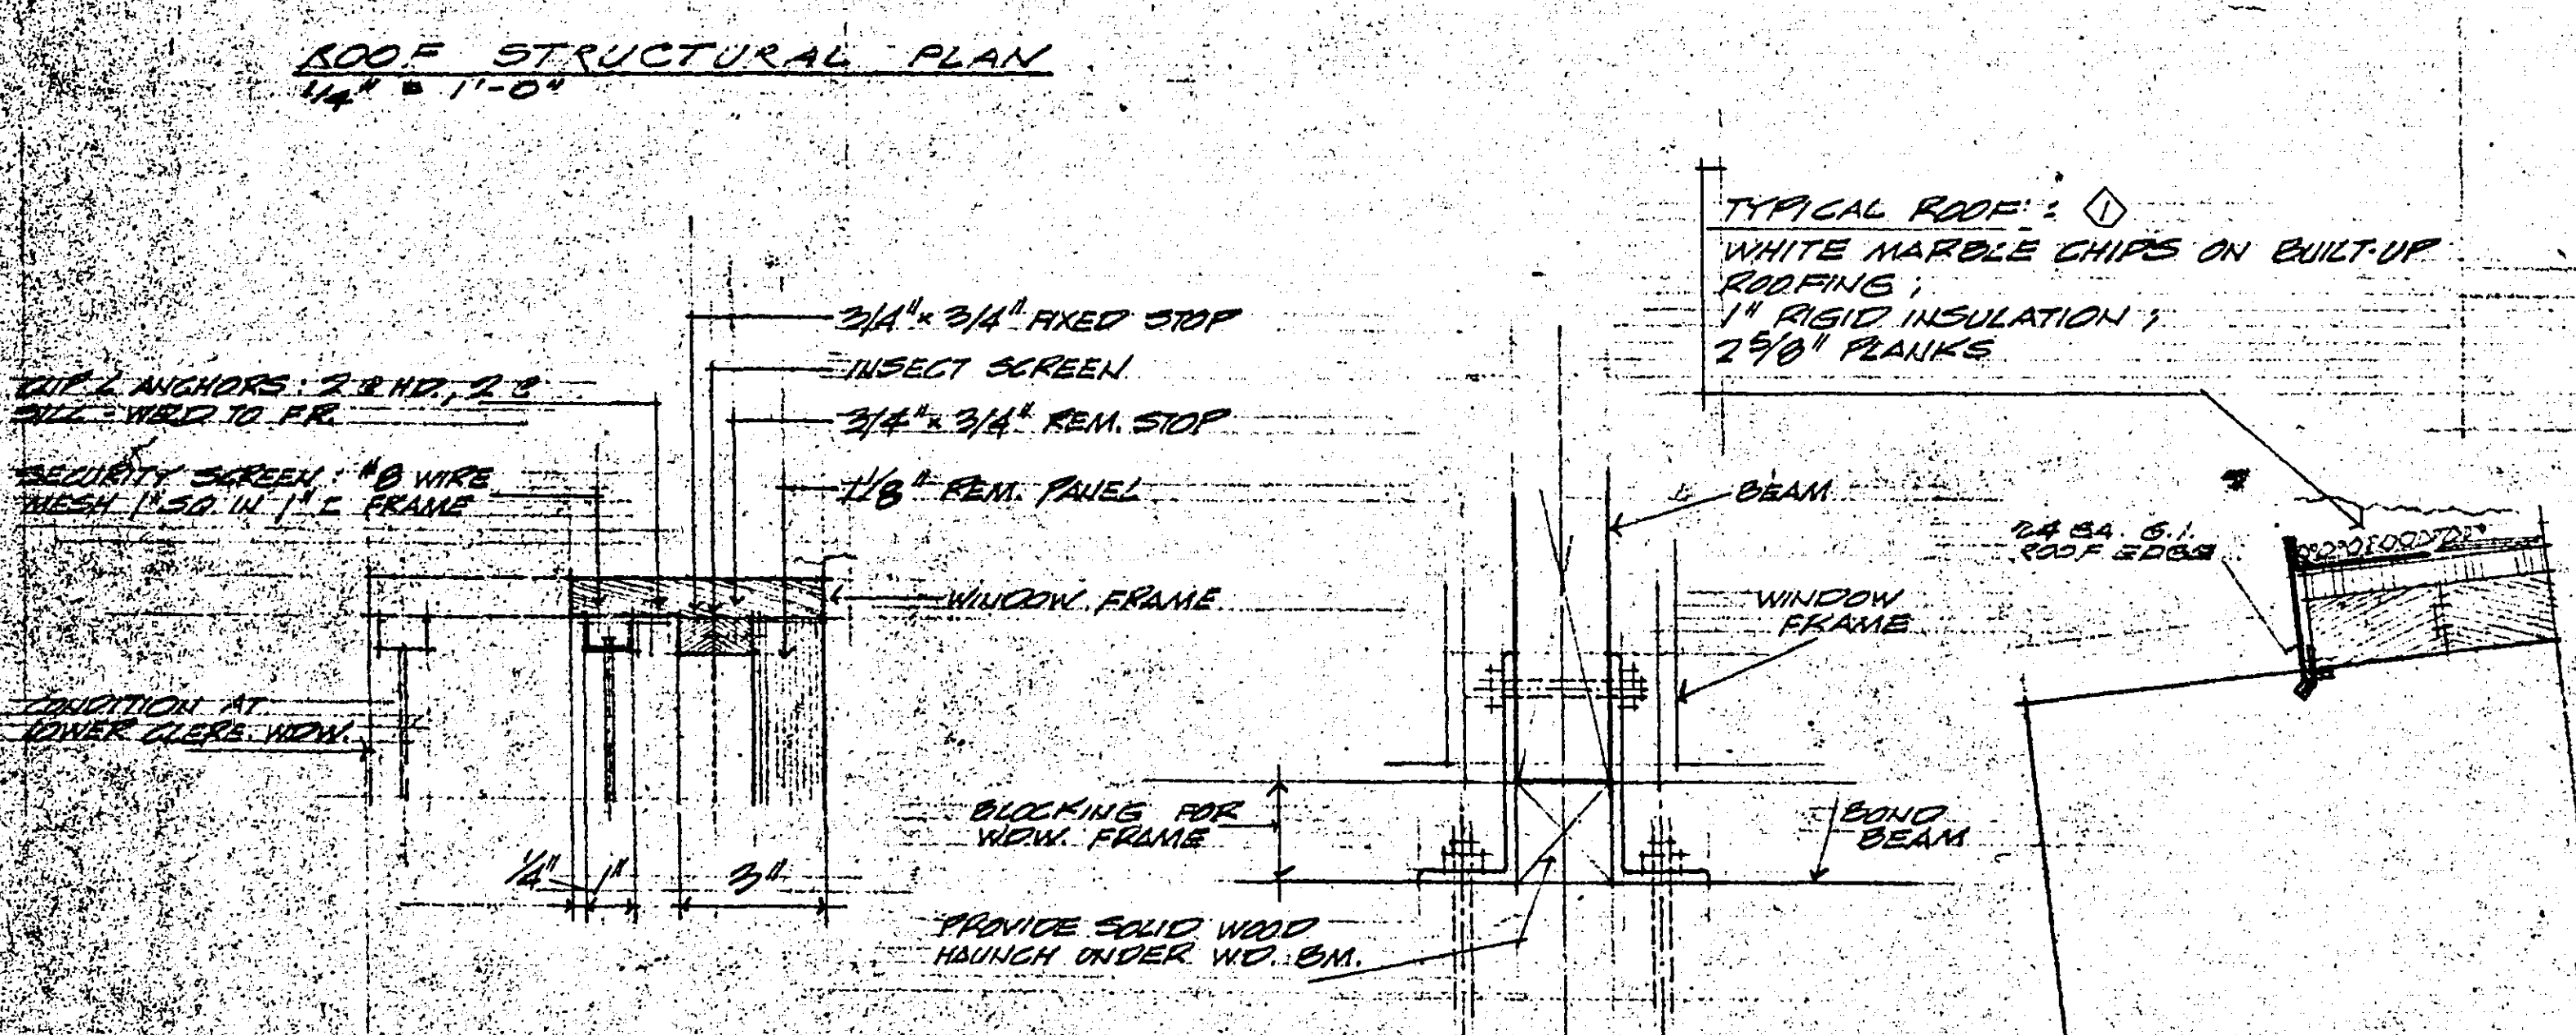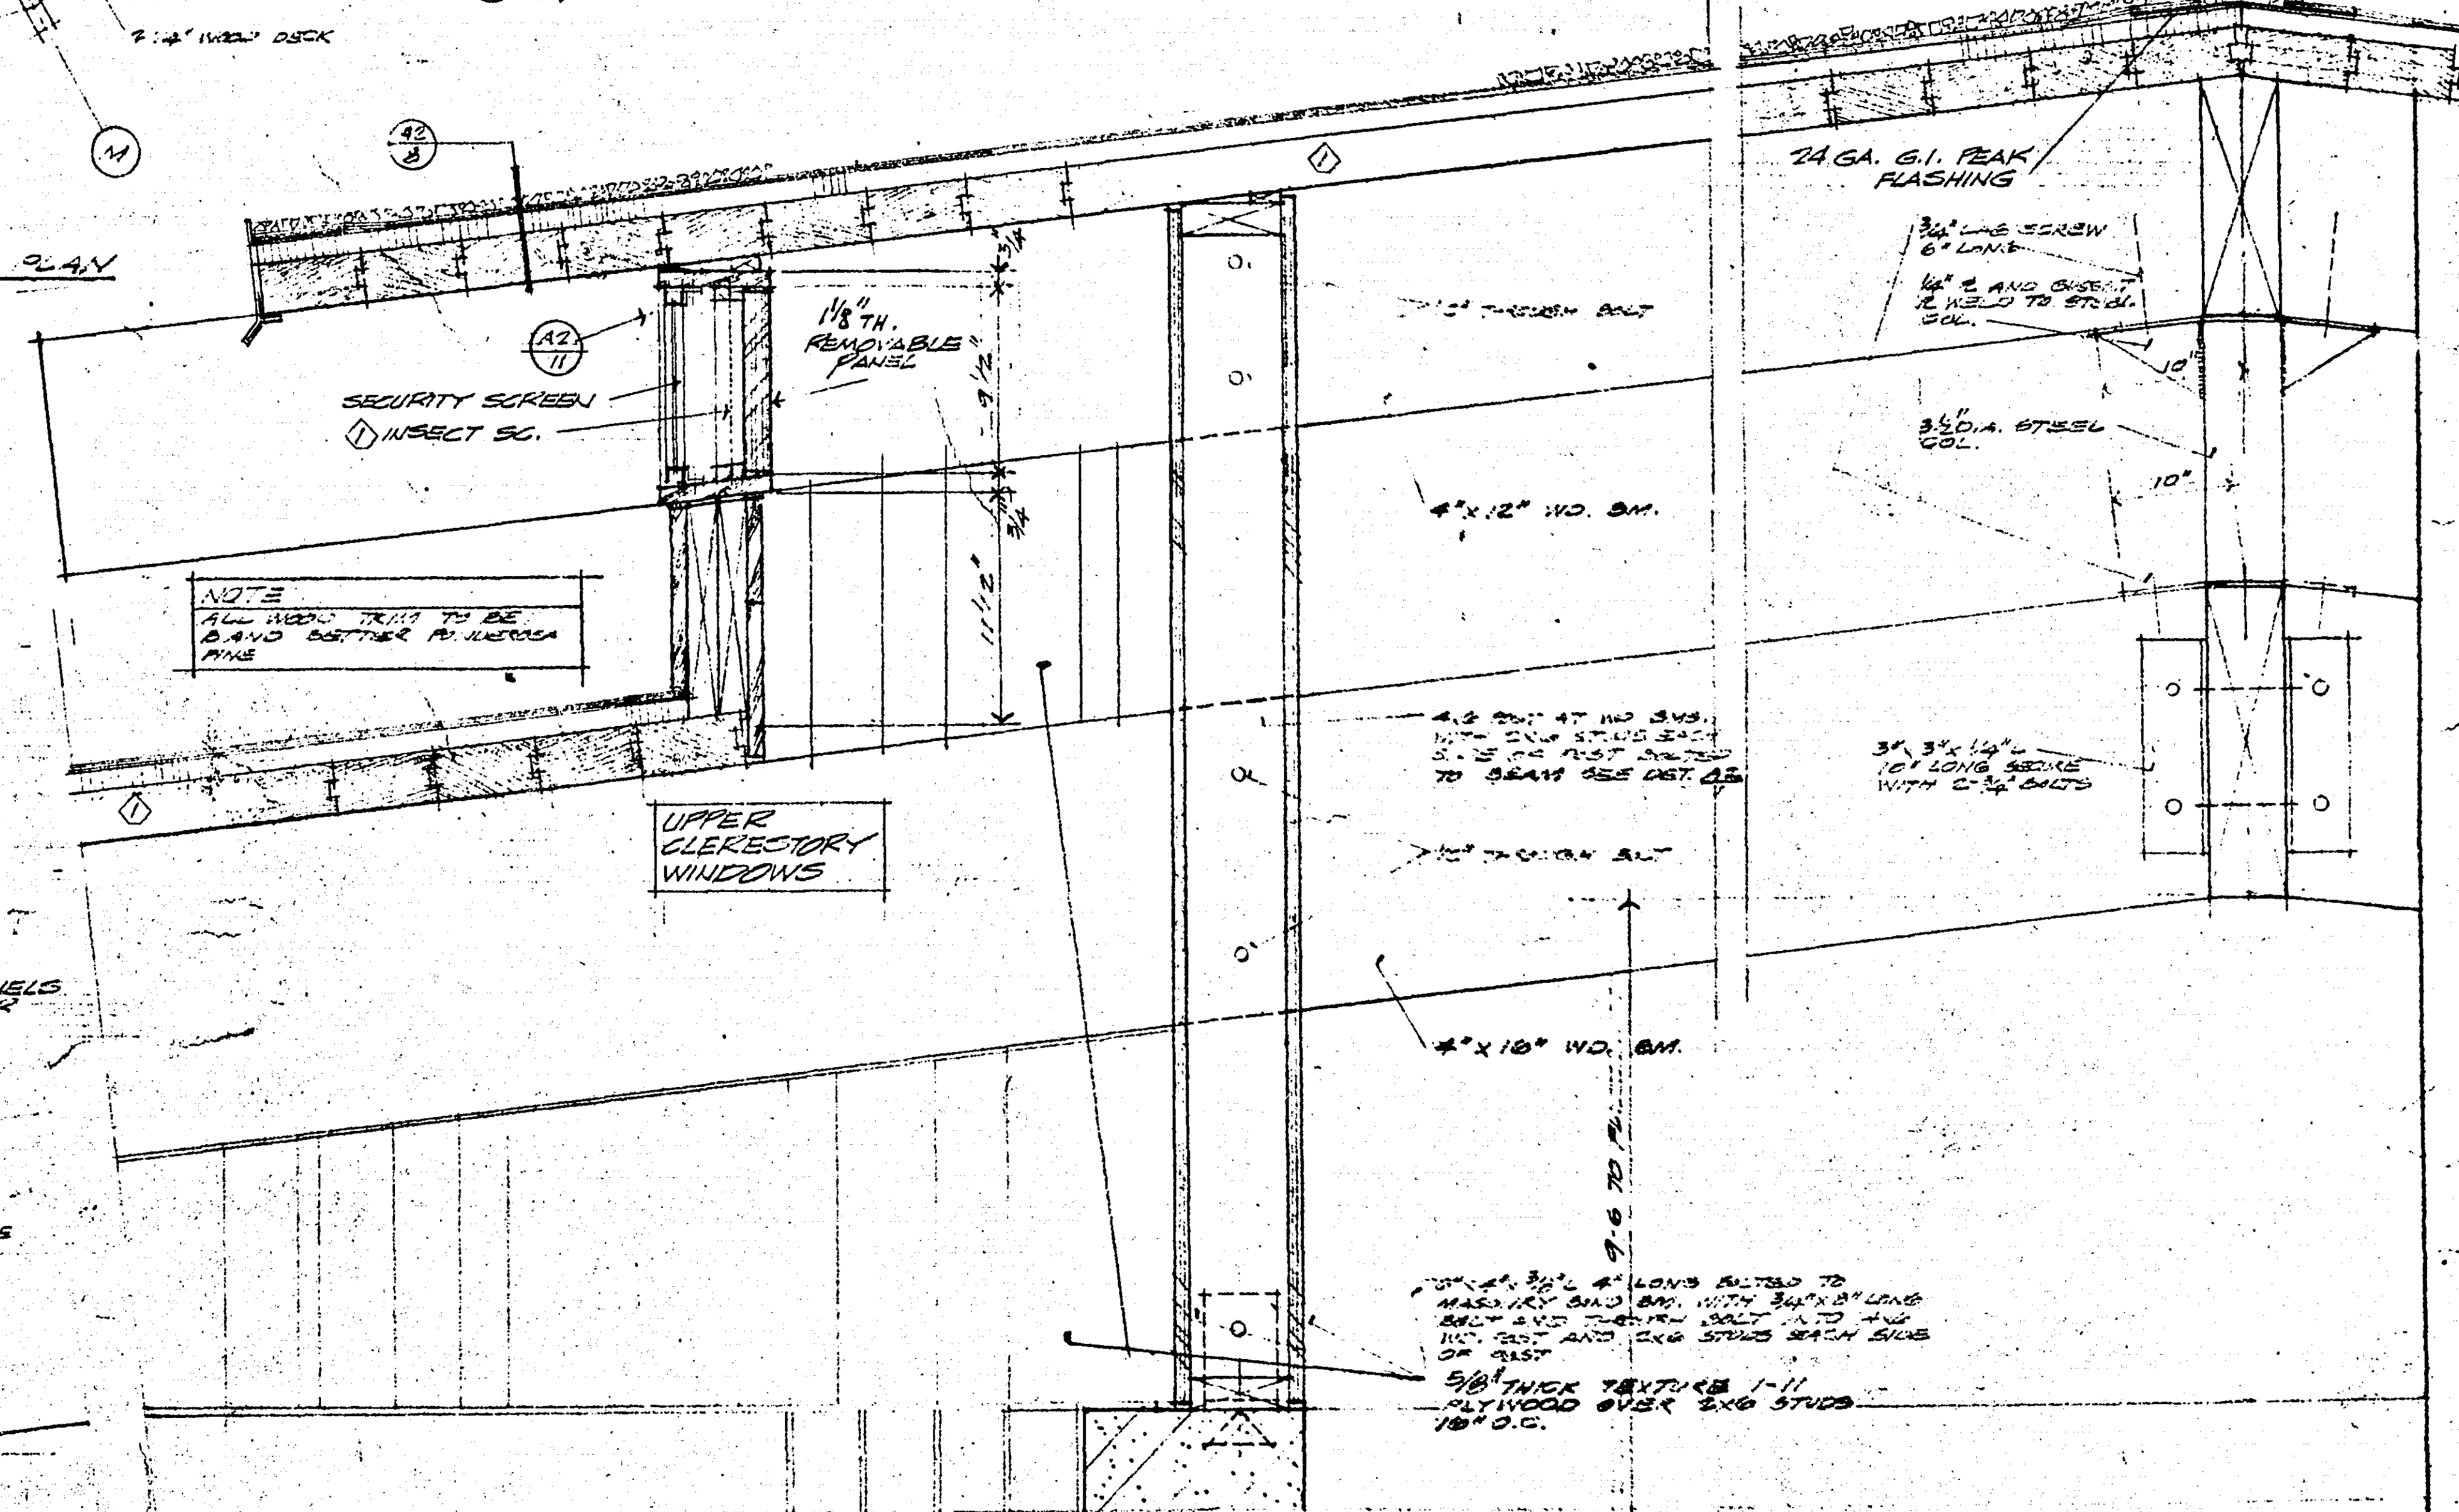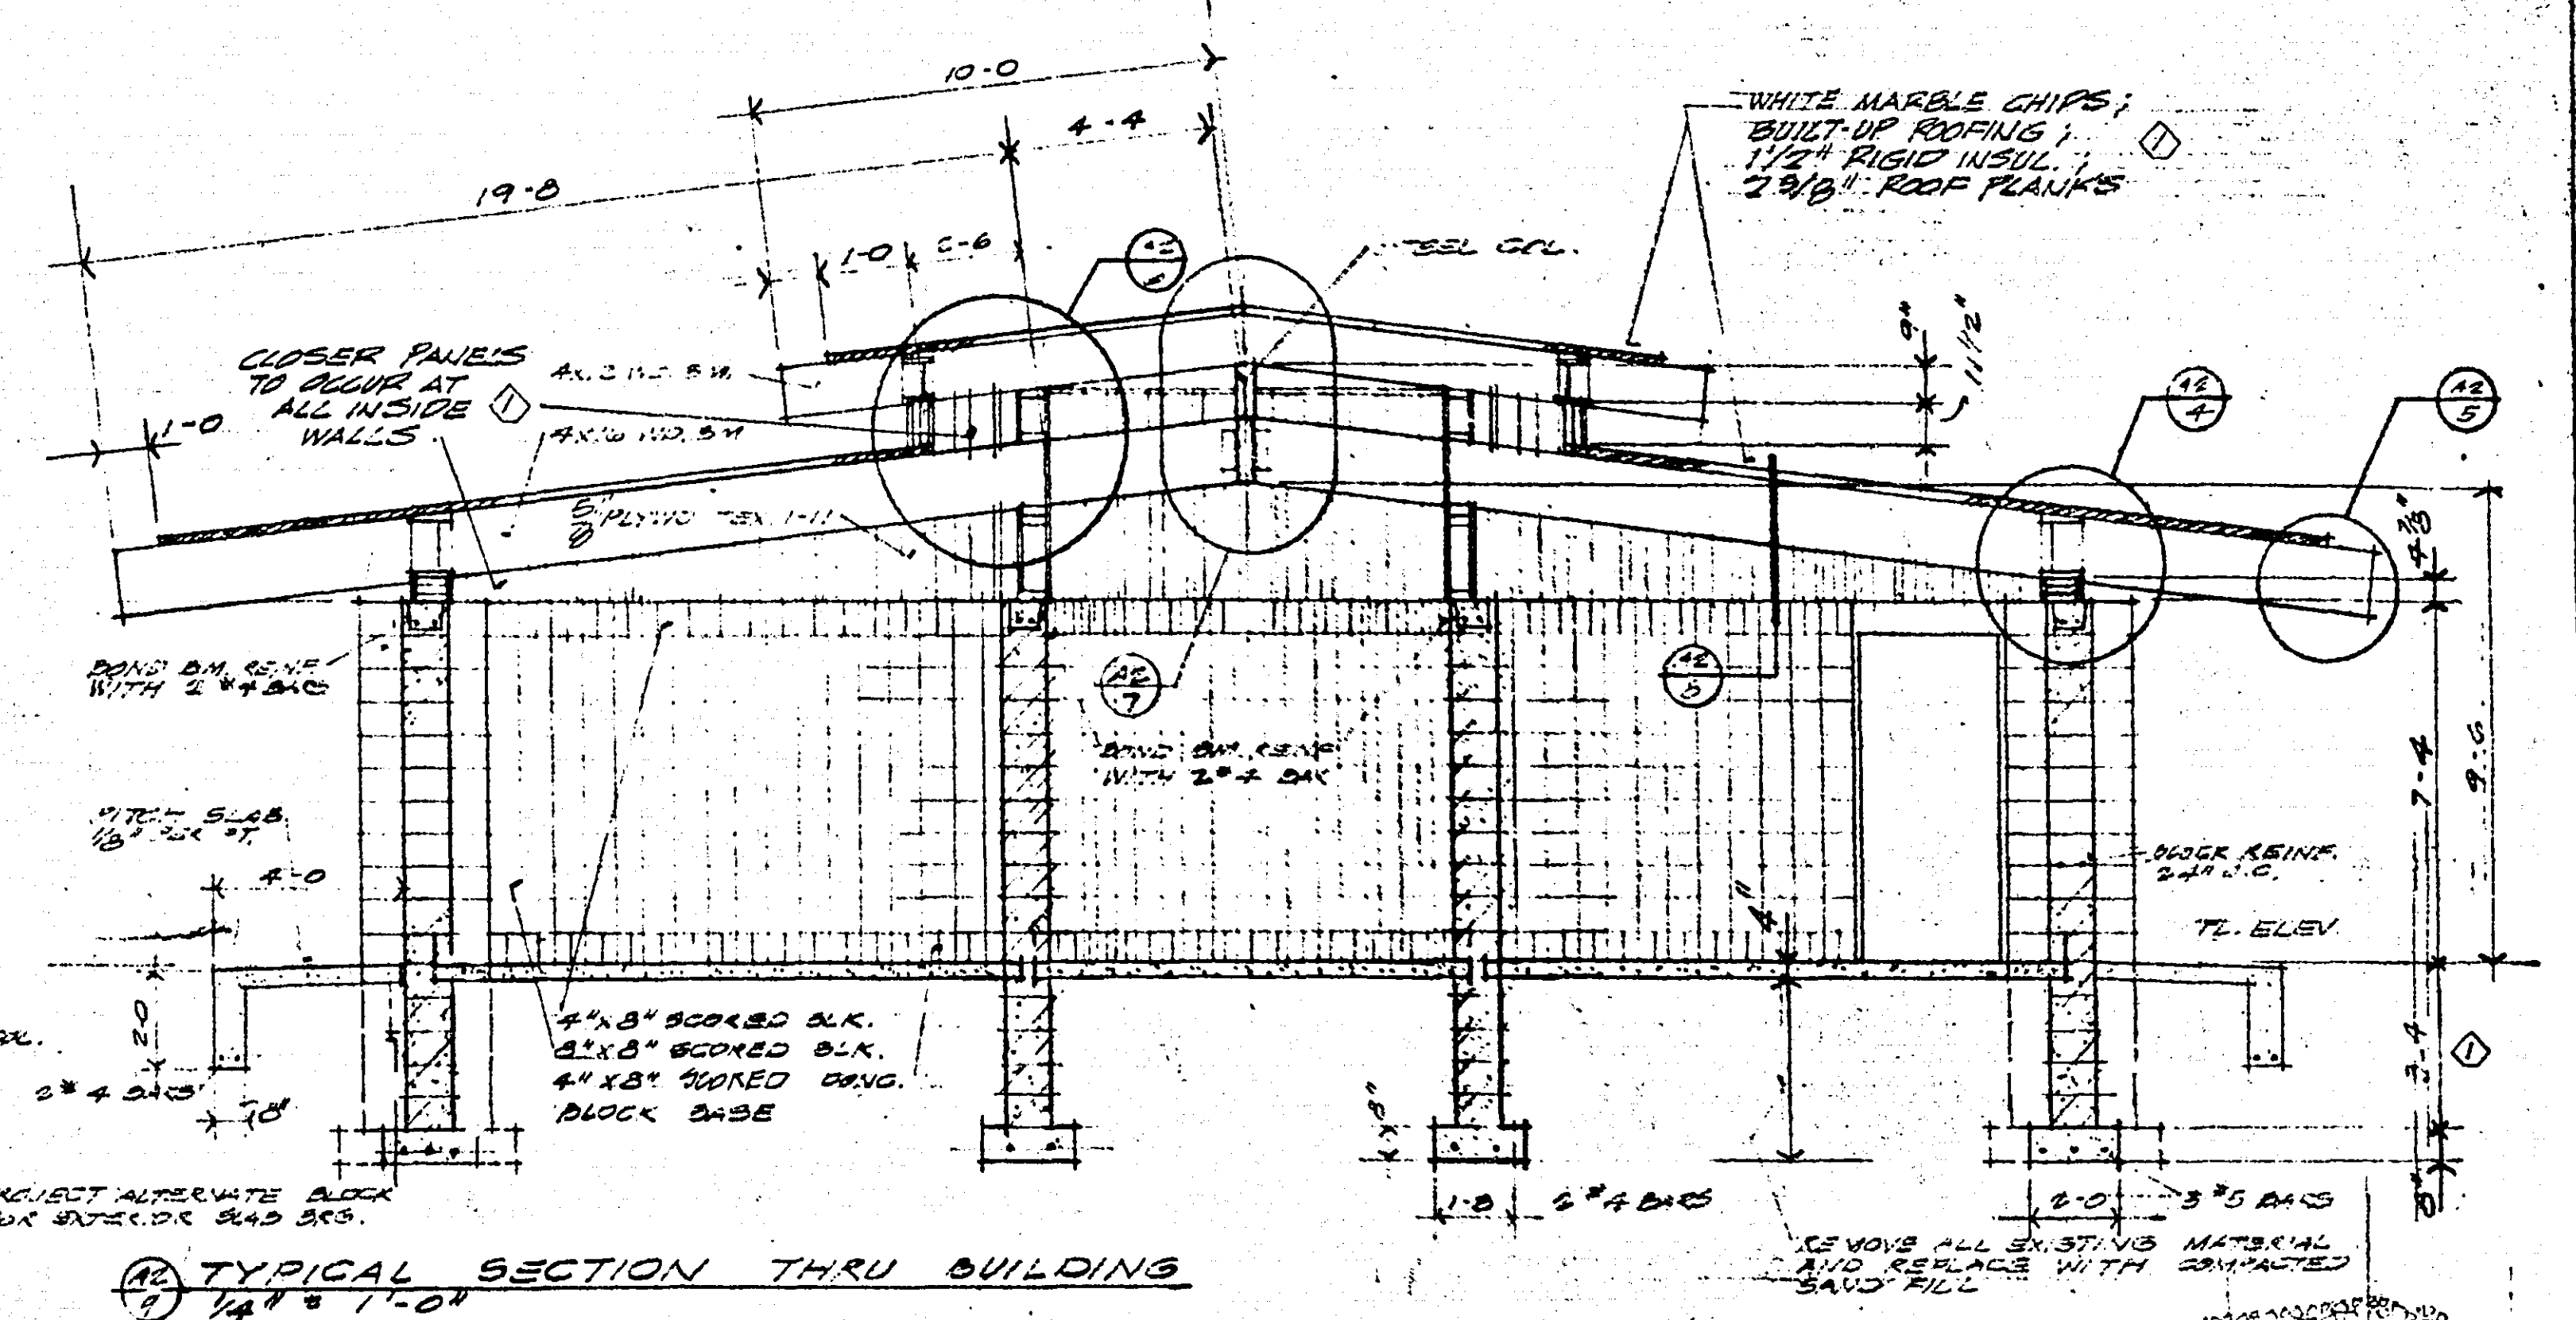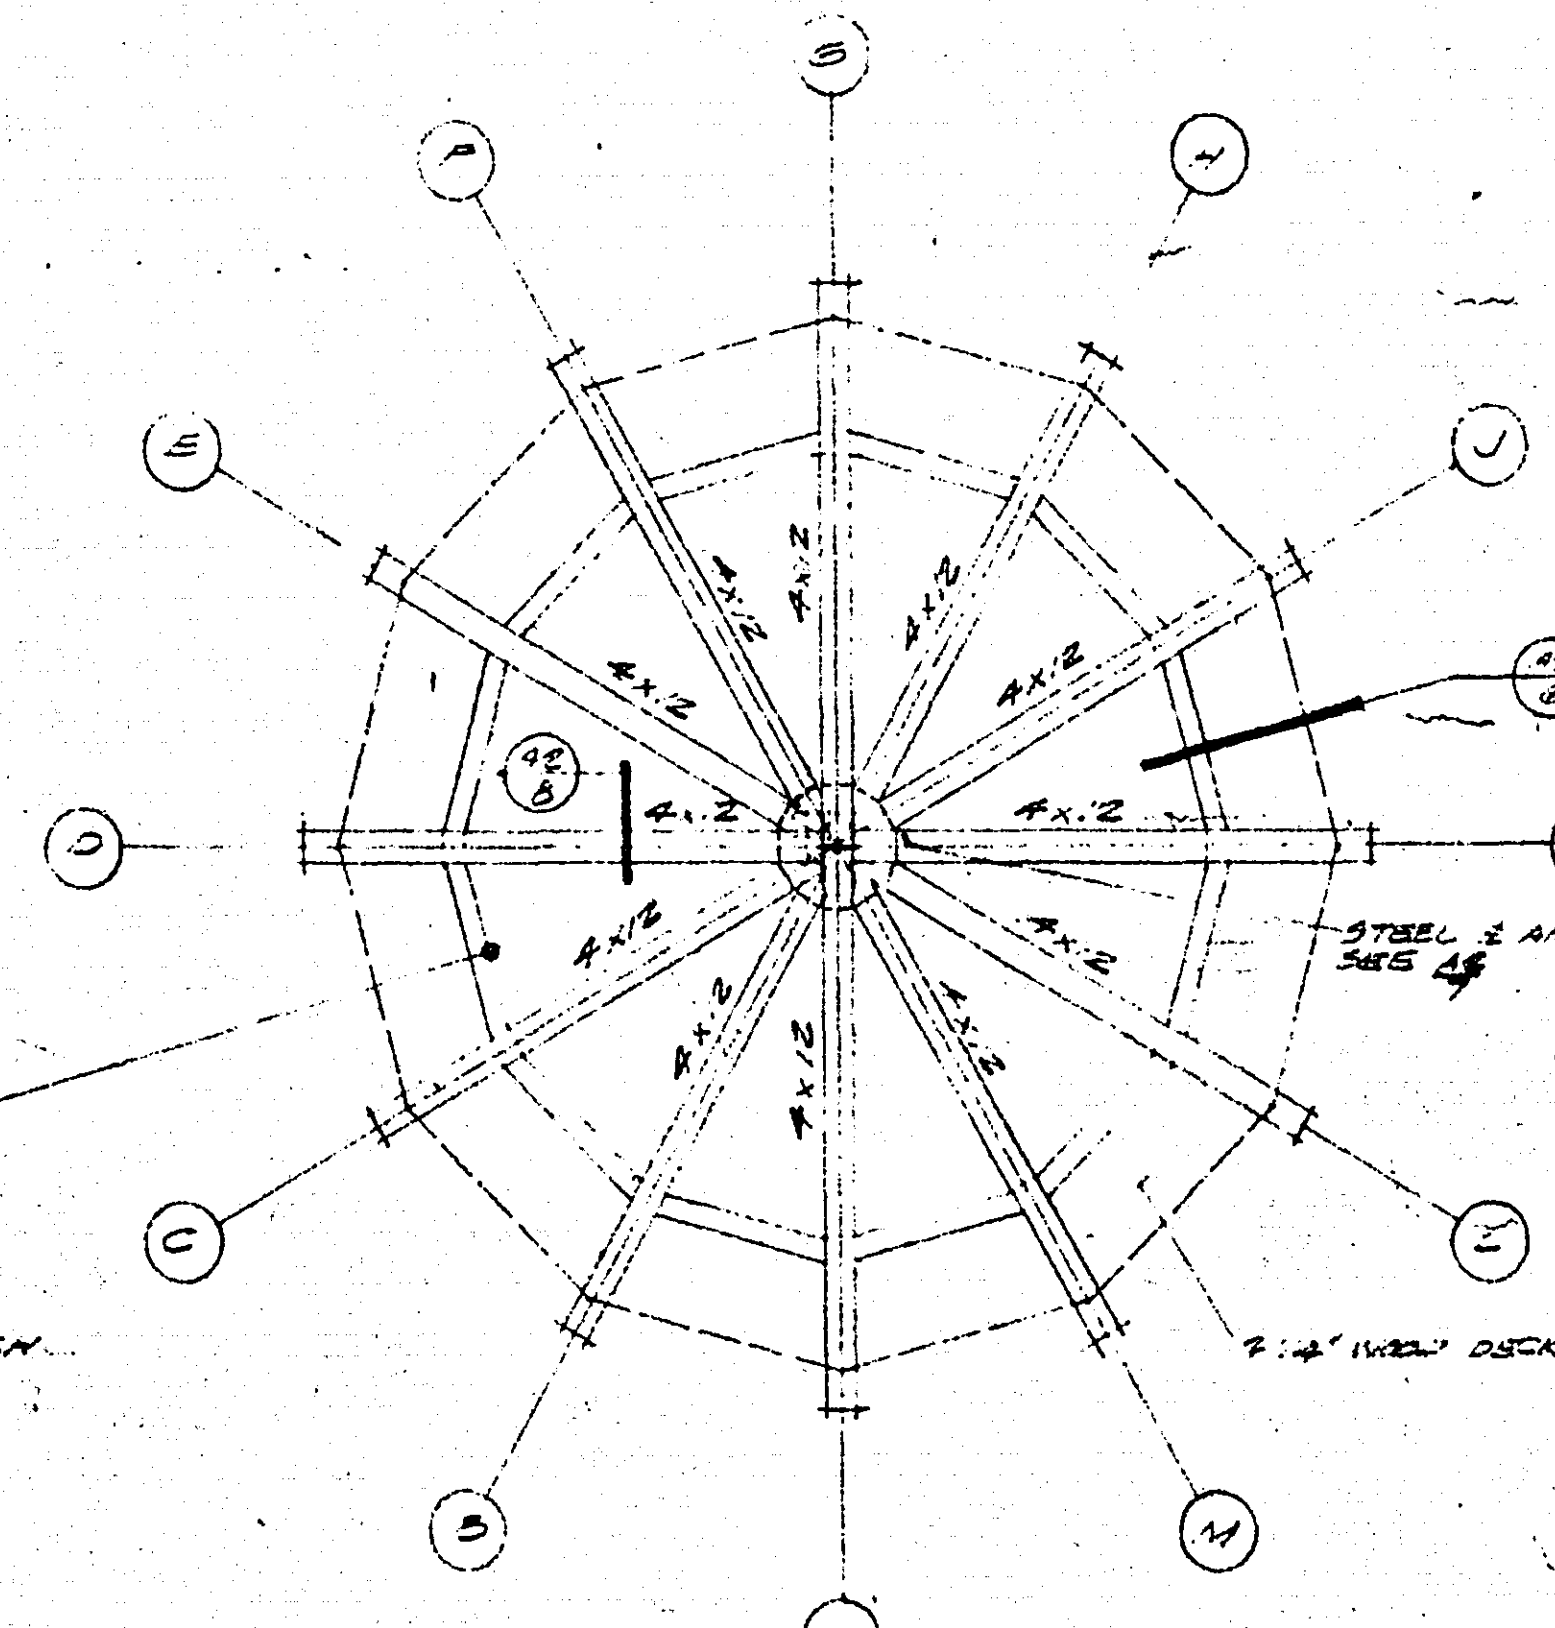[illegible]


KEFEATORY BUILDING FOR RAMSEY COUNTY
LAKE JOSEPHINE - RAMSEY COUNTY MINNESOTA
DEANE BAKLEY, RAMSEY COUNTY, MINNESOTA

① GENERAL REVISION. RFD 6-12-68


PLAGENS MCGEE ANDERSON SIGVETEN INC.

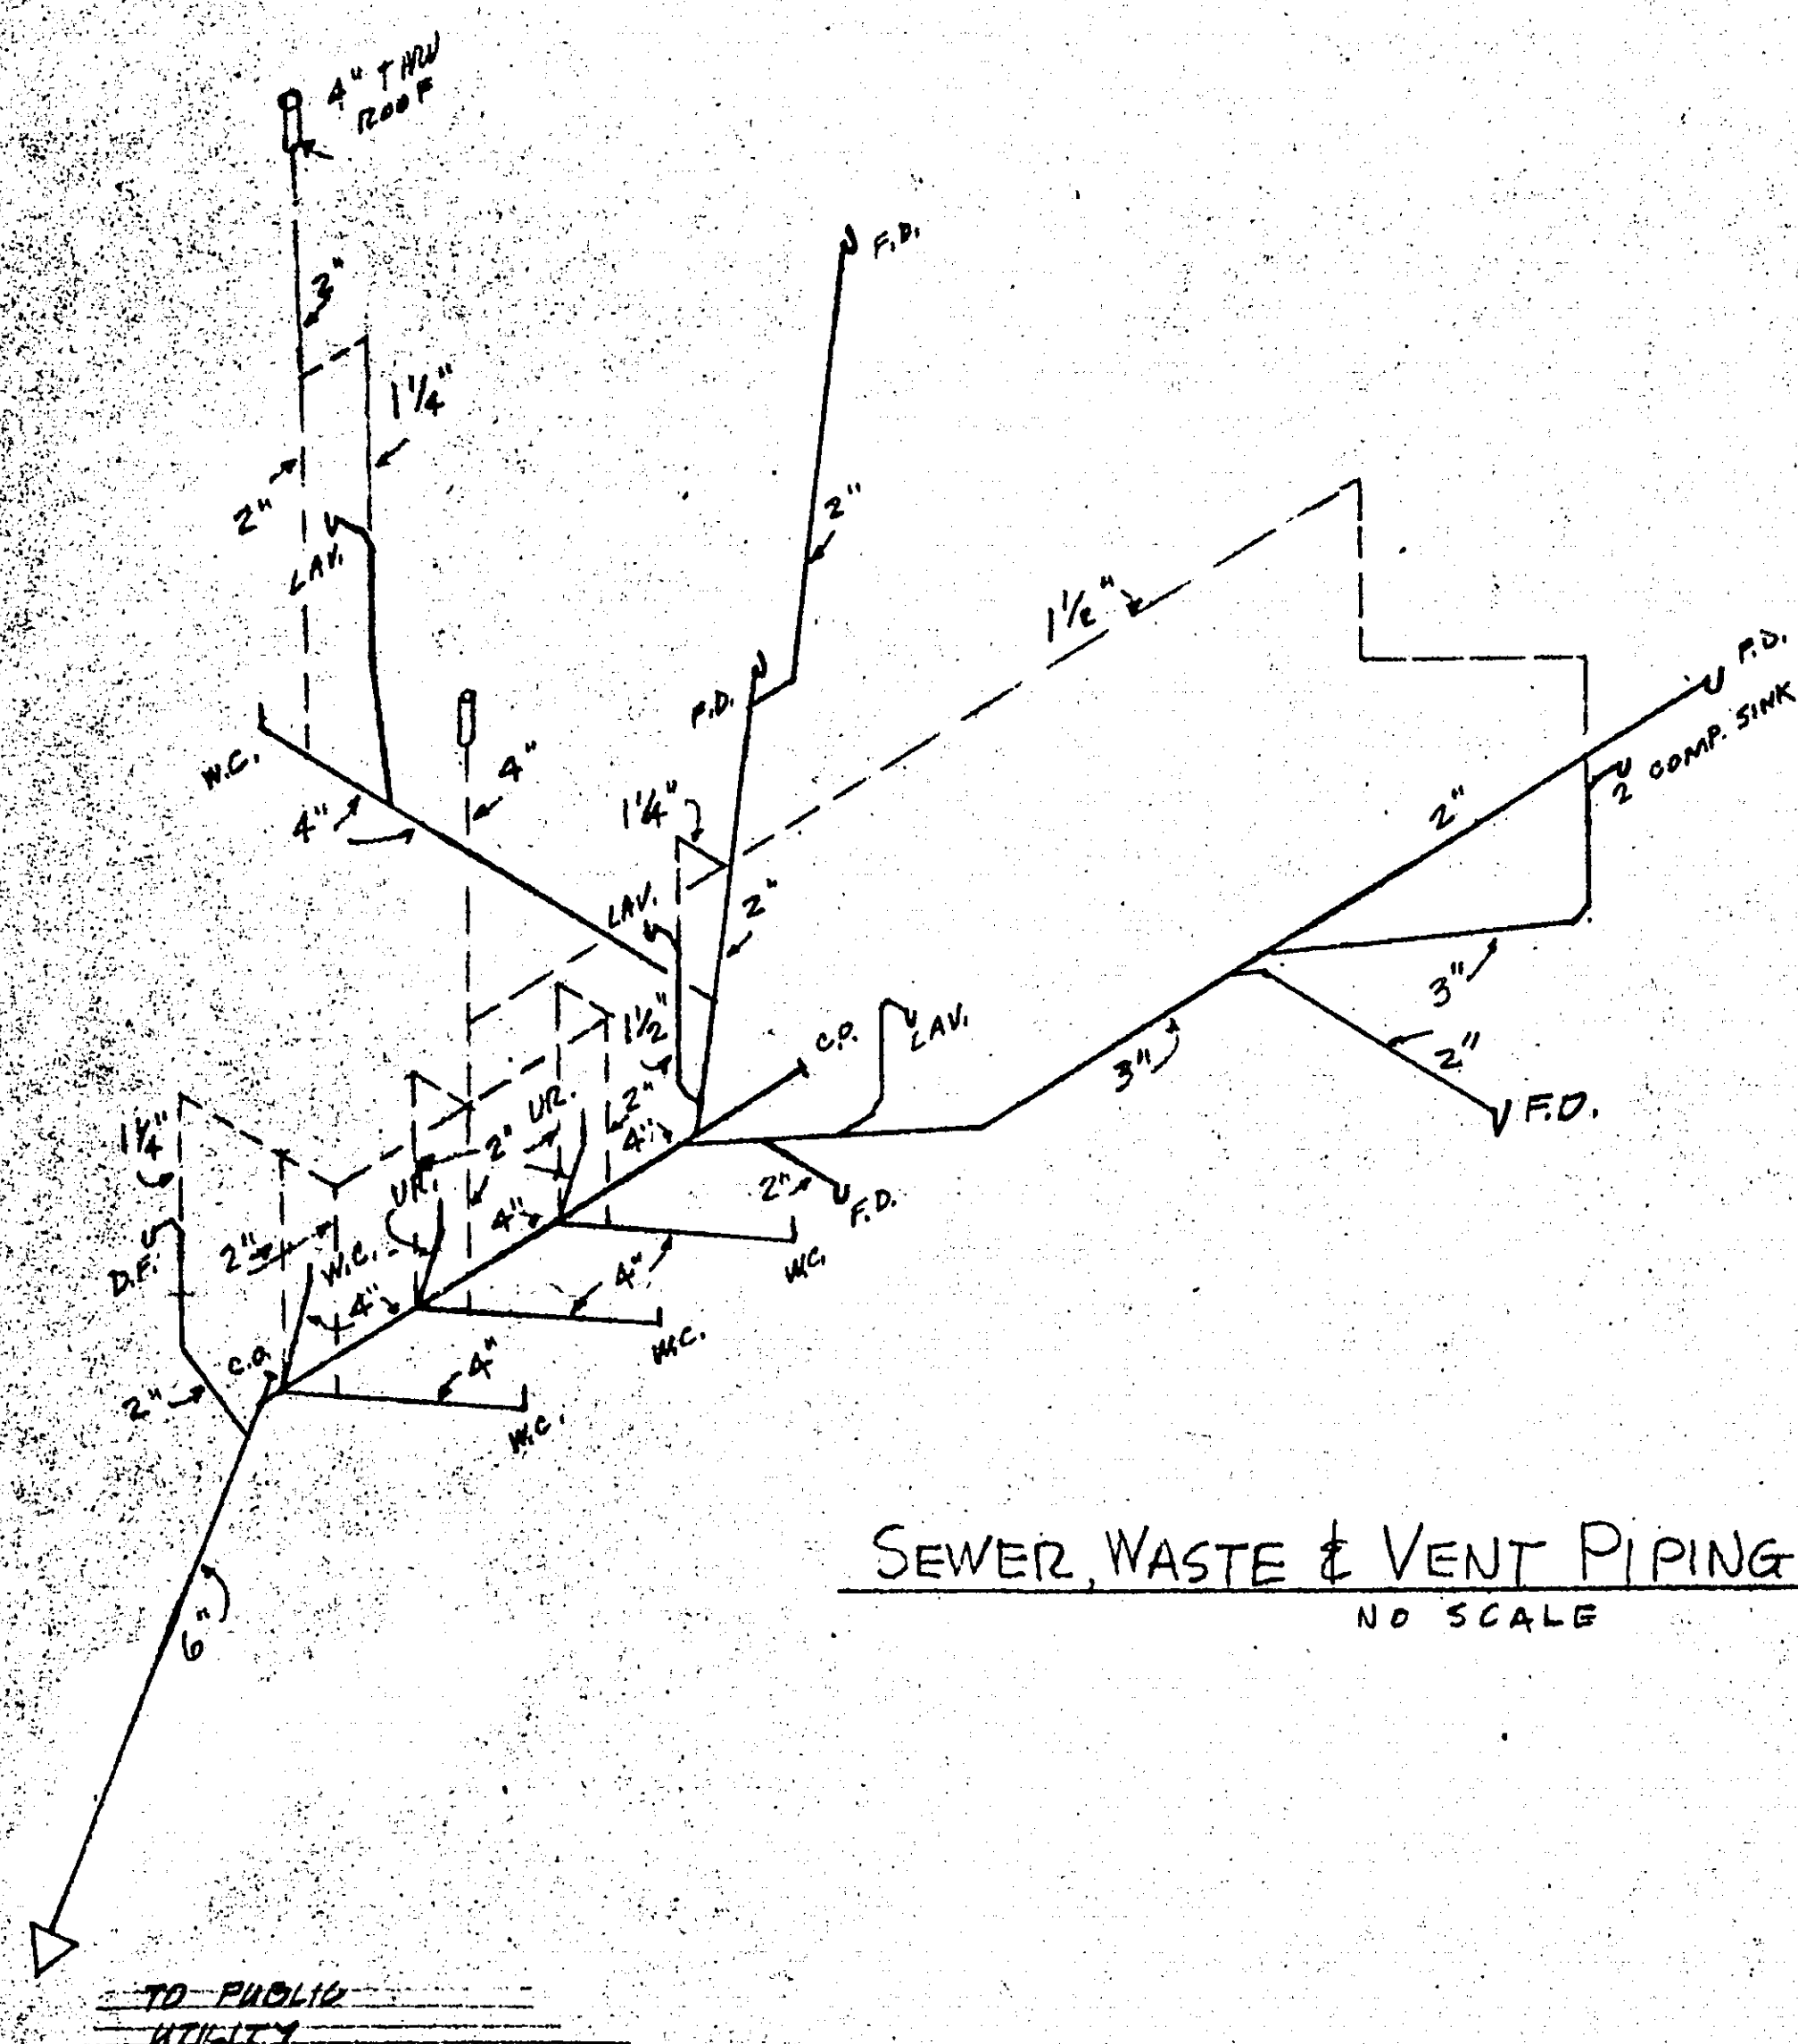

SEWER, WASTE & VENT PIPING RISER
NO SCALE

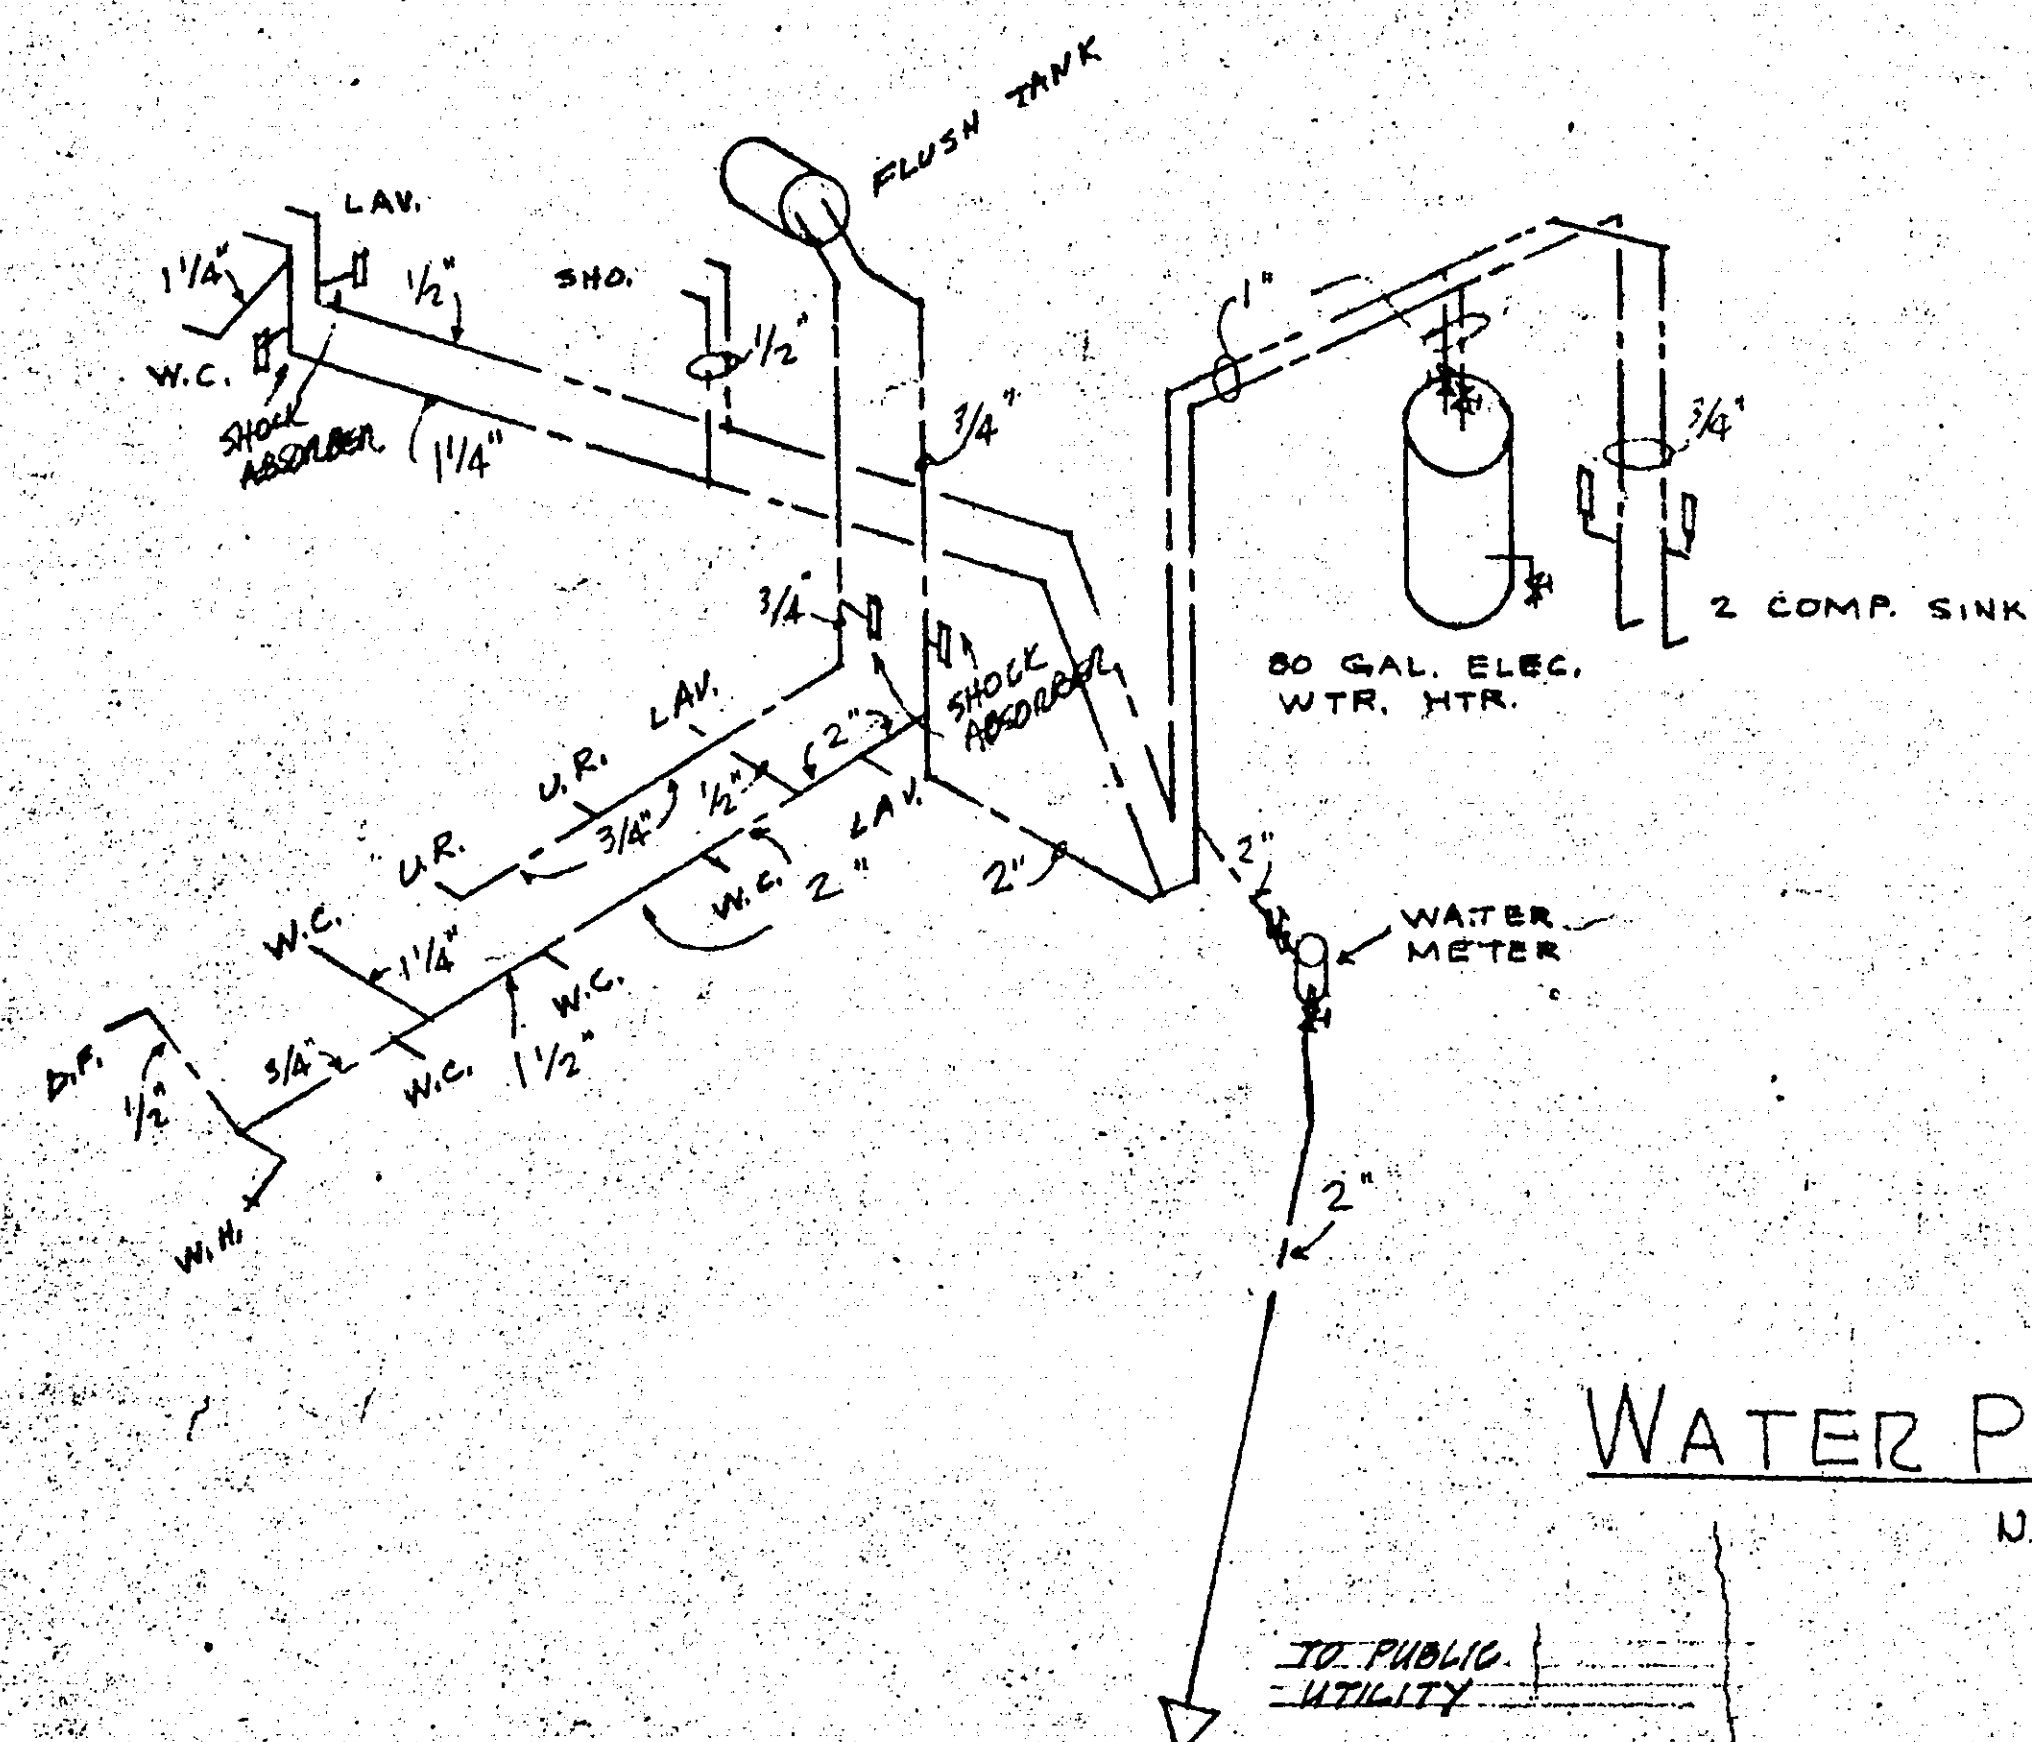

WATER PIPING RISER
NO SCALE

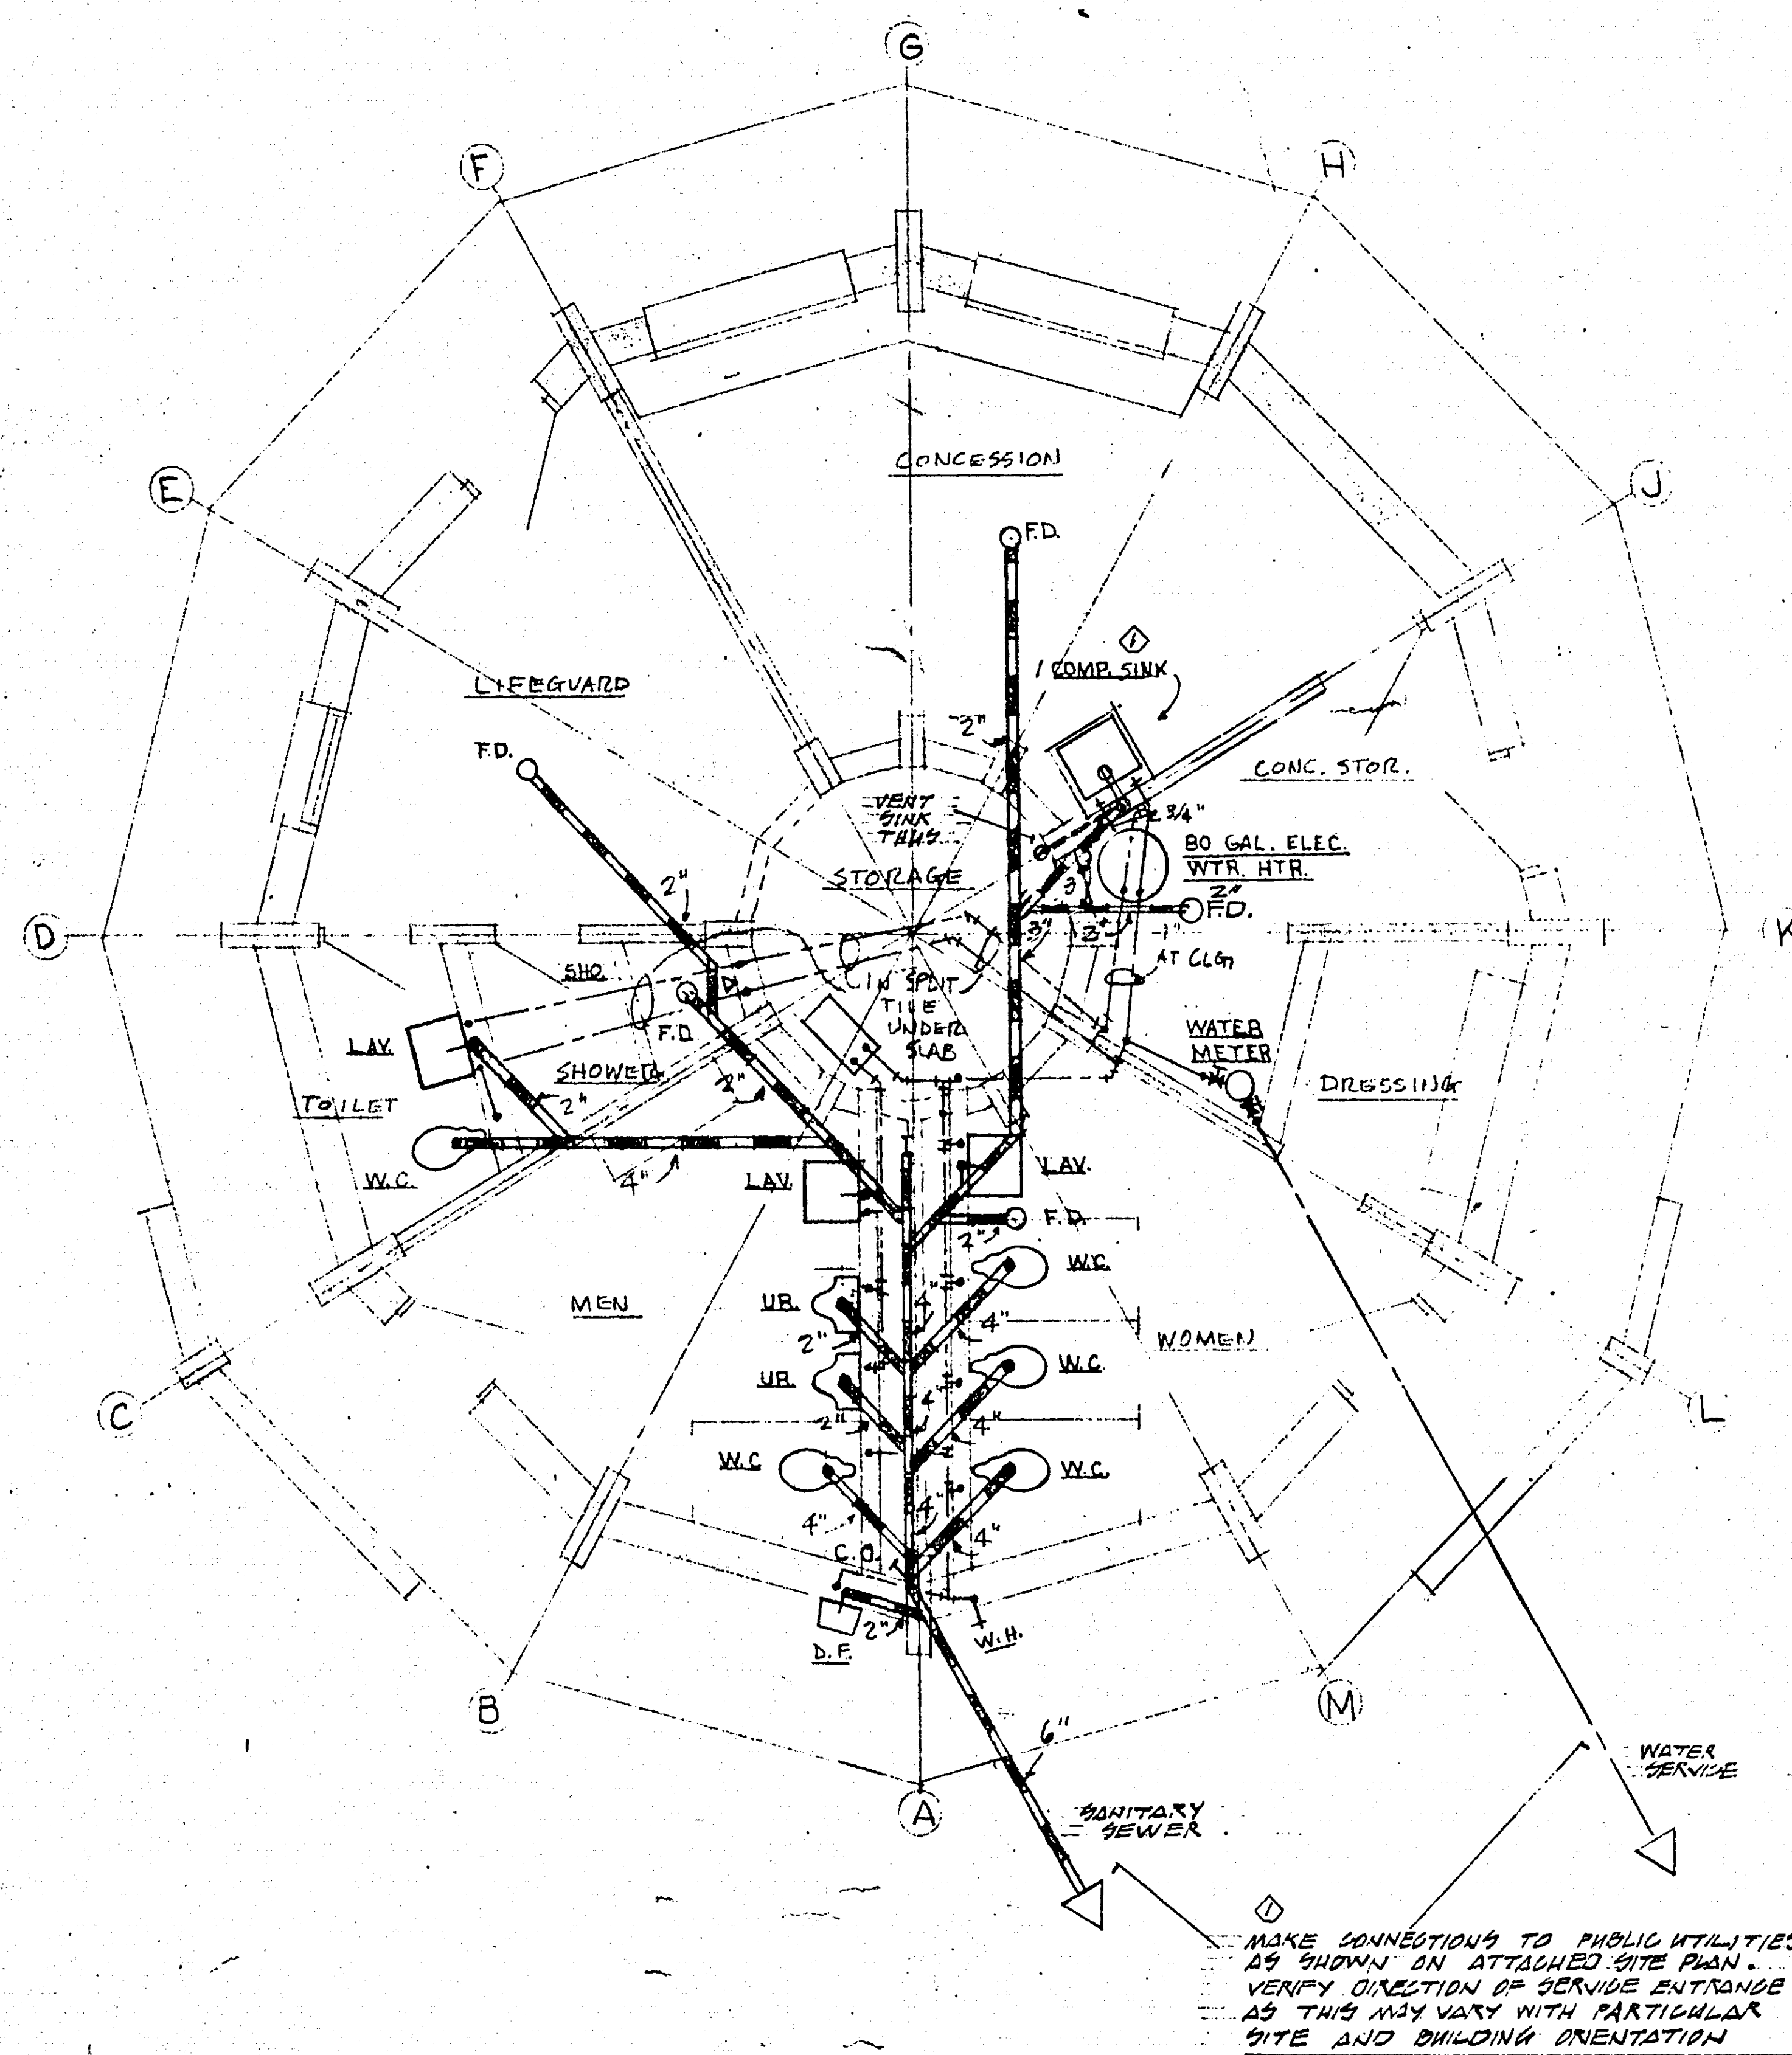

FLOOR PLAN
SCALE 1/4" = 1'-0"

MAKE CONNECTIONS TO PUBLIC UTILITIES
AS SHOWN ON ATTACHED SITE PLAN.
VERIFY DIRECTION OF SERVICE ENTRANCE
AS THIS MAY VARY WITH PARTICULAR
SITE AND BUILDING ORIENTATION